

STATE OF CALIFORNIA DEPARTMENT OF TRANSPORTATION

Dist	COUNTY	ROUTE	POST MILES TOTAL PROJECT	SHEET No.	TOTAL SHEETS
02	Sis	5	R57.8/R58.5	1	106


 
INDEX OF PLANS

SHEET No.	DESCRIPTION
1	TITLE AND LOCATION MAP
2	TYPICAL CROSS SECTIONS
3-7	LAYOUTS
8-12	CONSTRUCTION DETAILS
13	UTILITY PLANS
14	CONSTRUCTION AREA SIGNS
15-32	STAGE CONSTRUCTION PLANS
33	TRAFFIC HANDLING DETAILS
34	DETOUR PLAN
35-44	PAVEMENT DELINEATION PLANS
45	SUMMARY OF QUANTITIES
46-48	ELECTRICAL PLANS
49-88	REVISED STANDARD PLANS
STRUCTURES	
89-106	STRUCTURE PLANS

PROJECT PLANS FOR CONSTRUCTION ON STATE HIGHWAY IN SISKIYOU COUNTY NEAR HORN BROOK FROM 0.3 MILE SOUTH OF KLAMATH RIVER ROAD UNDERCROSSING TO 0.5 MILE NORTH OF KLAMATH RIVER ROAD UNDERCROSSING

TO BE SUPPLEMENTED BY STANDARD PLANS DATED 2010

THE STANDARD PLANS LIST APPLICABLE TO THIS CONTRACT IS INCLUDED IN THE NOTICE TO BIDDERS AND SPECIAL PROVISIONS BOOK.

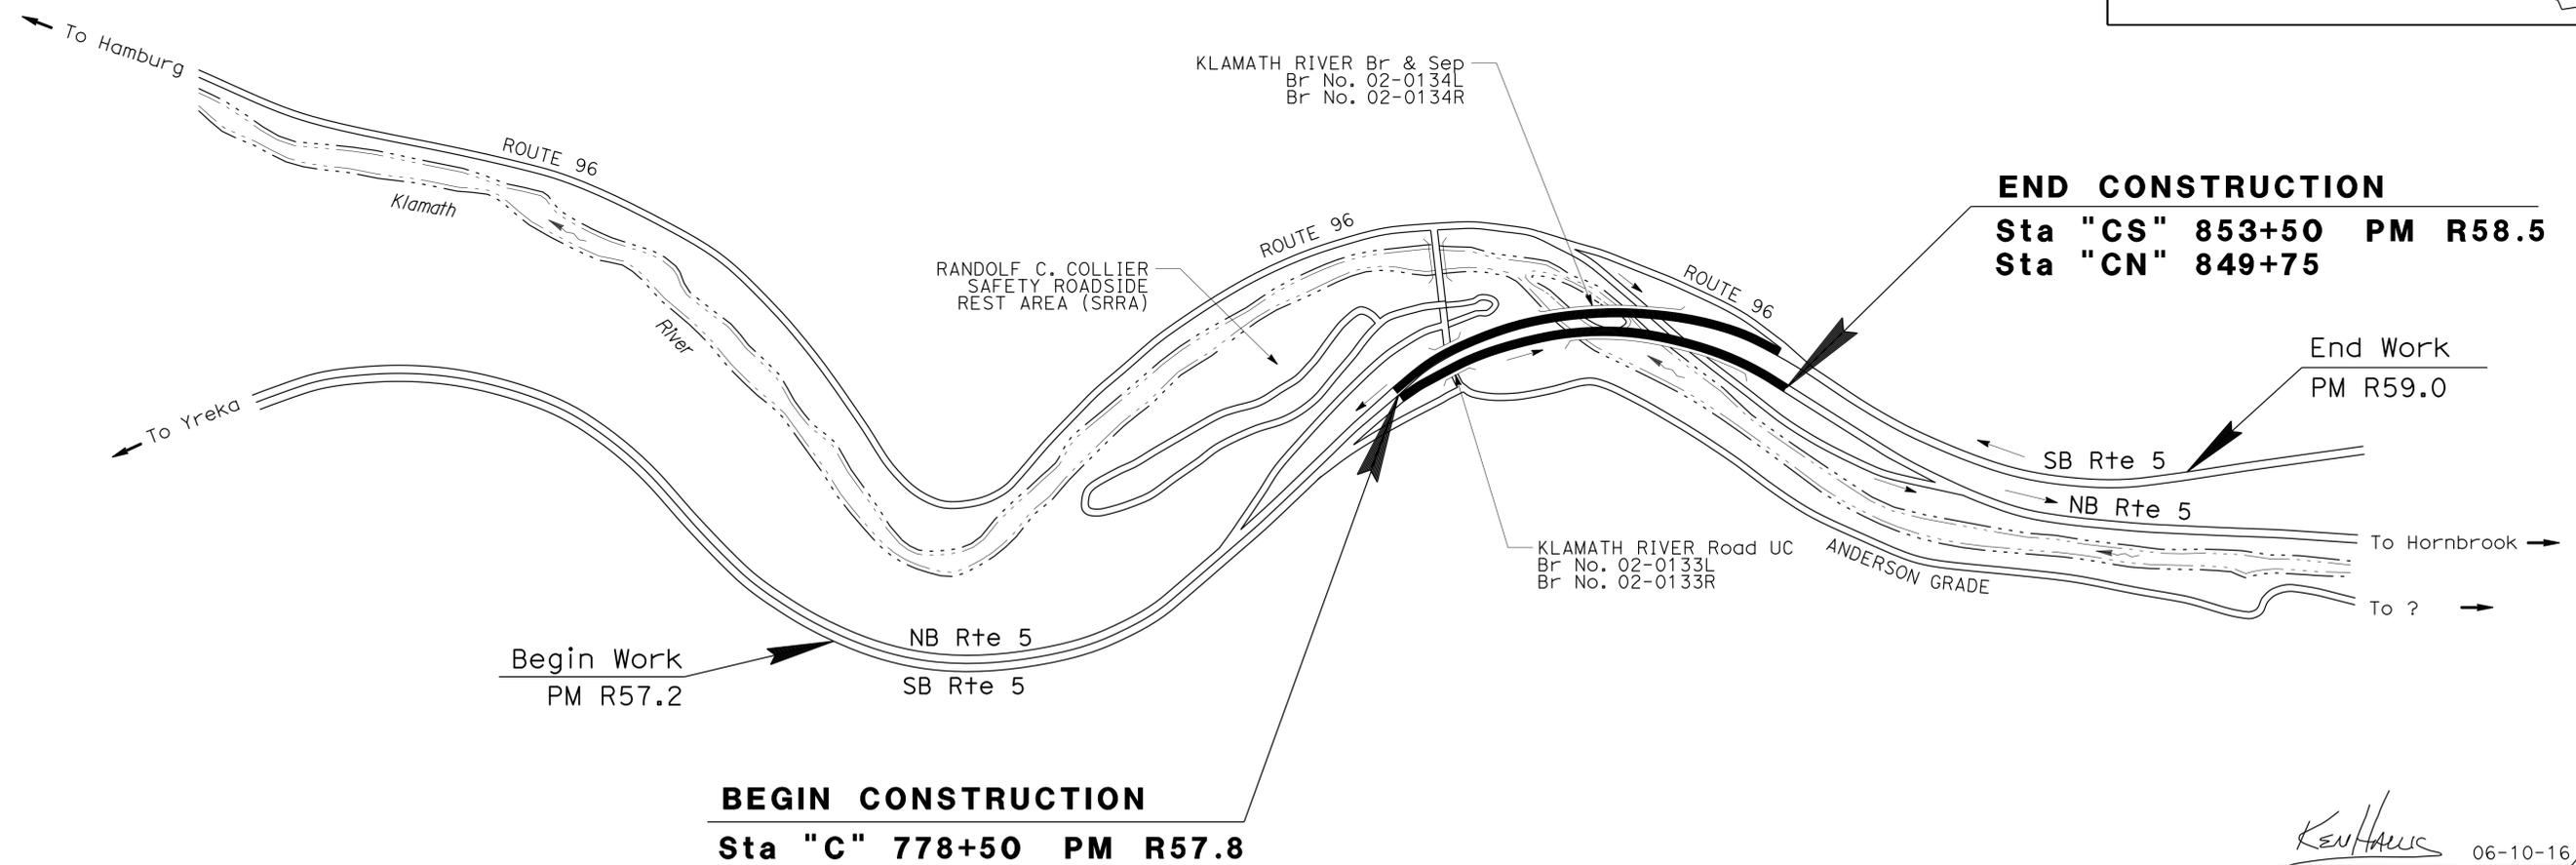

1 REPLACED PER ADDENDUM No. 1 DATED OCTOBER 19, 2016

PROJECT ENGINEER: *Ken Hallis* DATE: 06-10-16
 REGISTERED CIVIL ENGINEER
 No. C38203
 Exp. 3-31-17
 CIVIL
 STATE OF CALIFORNIA
 June 15, 2016
 PLANS APPROVAL DATE
 THE STATE OF CALIFORNIA OR ITS OFFICERS OR AGENTS SHALL NOT BE RESPONSIBLE FOR THE ACCURACY OR COMPLETENESS OF SCANNED COPIES OF THIS PLAN SHEET.

CONTRACT No.	02-4F58U4
PROJECT ID	0215000021

THE CONTRACTOR SHALL POSSESS THE CLASS (OR CLASSES) OF LICENSE AS SPECIFIED IN THE "NOTICE TO BIDDERS."

NO SCALE



USERNAME => s115152 DGN FILE => 24f58uab001.dgn

UNIT 0316 PROJECT NUMBER & PHASE 02 1500 0021 1

P:\pro\1\02\4F58U4\plans\pse\Addenda 1 10-04-16\24f58uab001.dgn

PROJECT MANAGER	ERIC AKANA
DESIGN MANAGER	ERIC ORR

LAST REVISION: DATE PLOTTED => 17-OCT-2016 TIME PLOTTED => 09:03 06-05-16