


Dist	COUNTY	ROUTE	POST MILES TOTAL PROJECT	SHEET No.	TOTAL SHEETS
07	LA	110	8.6/14.0	101	121

**Randell D. Hiatt**  
REGISTERED CIVIL ENGINEER

July 19, 2013  
PLANS APPROVAL DATE


THE STATE OF CALIFORNIA OR ITS OFFICERS OR AGENTS SHALL NOT BE RESPONSIBLE FOR THE ACCURACY OR COMPLETENESS OF SCANNED COPIES OF THIS PLAN SHEET.

REGISTERED PROFESSIONAL ENGINEER  
No. C50200  
Exp. 6-30-15  
CIVIL  
STATE OF CALIFORNIA

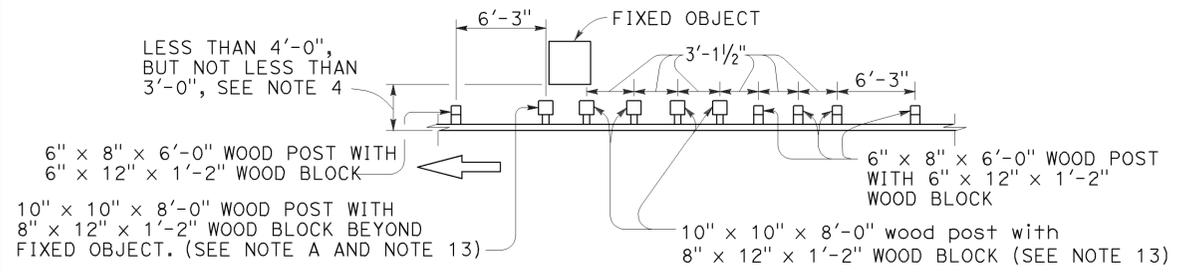


**NOTE A:** For a series of fixed objects (bridge columns, overhead sign supports, etc.) additional 10" x 10" x 8'-0" wood post with 8" x 12" x 1'-2" wood blocks at 3'-1/2" center to center spacing are to be used between fixed object(s).

**STRENGTHENED MIDWEST GUARDRAIL SYSTEM SECTIONS FOR FIXED OBJECT**

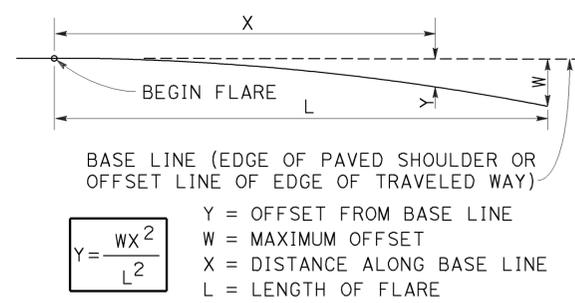


**PARABOLIC FLARE OFFSETS**

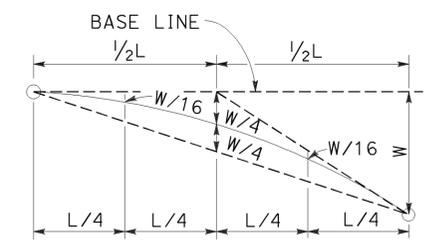


**TYPICAL PARABOLIC LAYOUT**

Use strengthened MGS sections with layout Types 16I or 16J Layouts where minimum clearance between the face of the MGS and fixed object(s) is less than 4'-0", but not less than 3'-0". See Note 4.

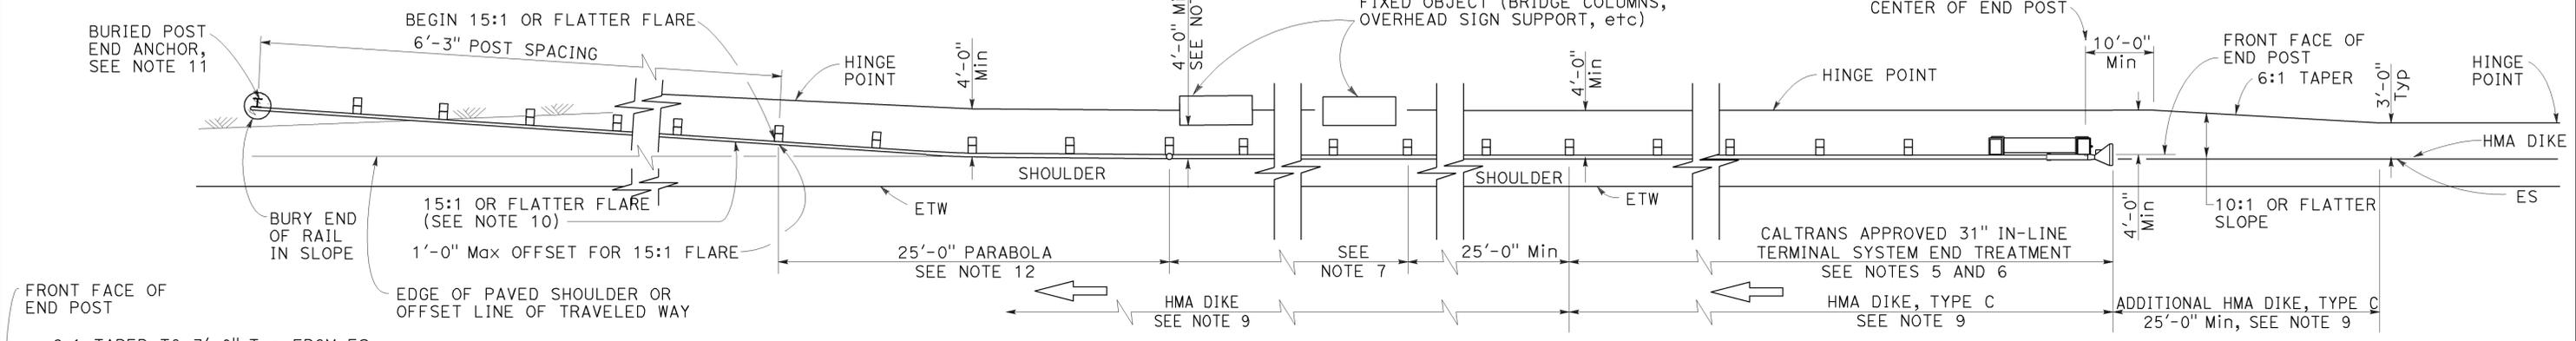

**TYPE 16I LAYOUT**

(MGS installation at roadside fixed object or objects with 31" in-line end treatment and a buried end anchor treatment at the ends of railing) See Note 8

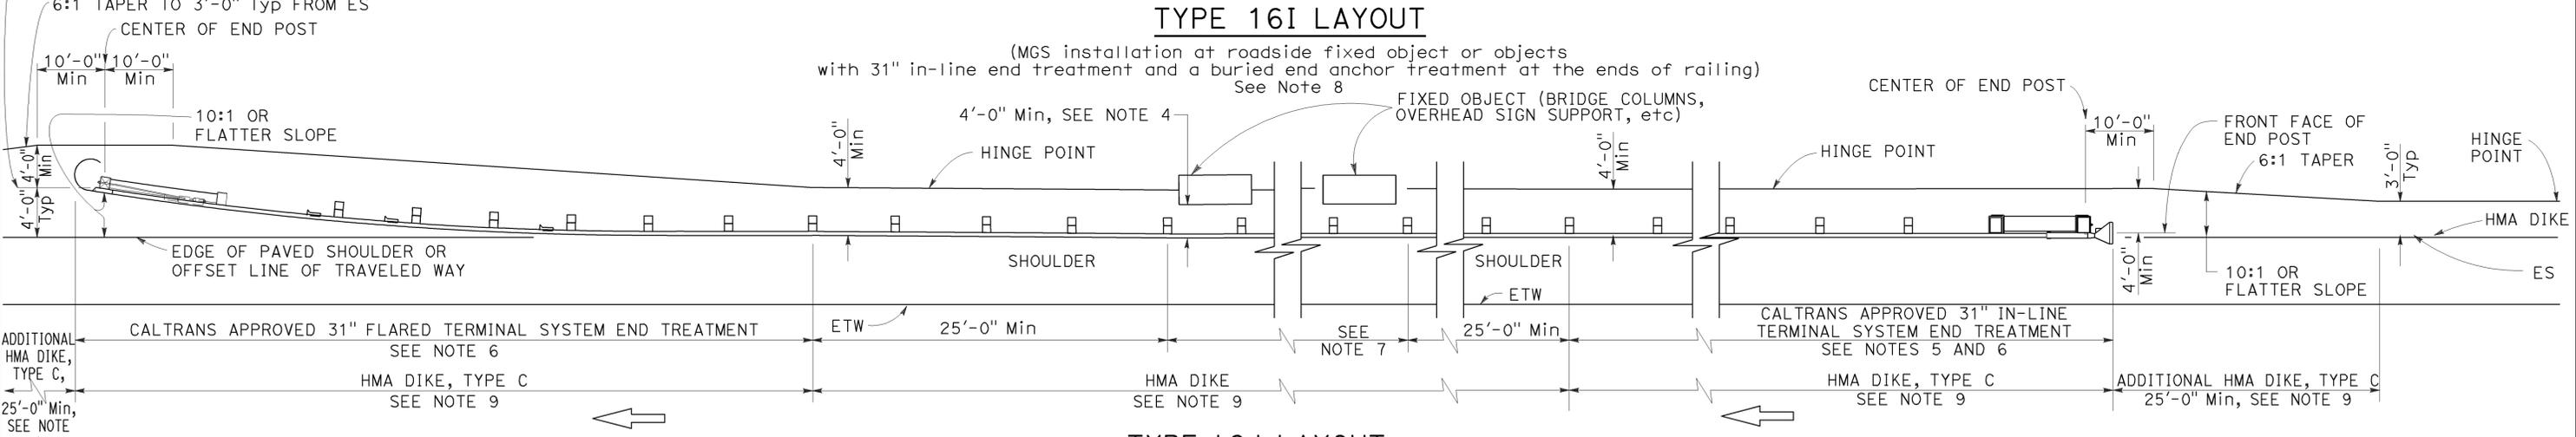

**TYPE 16J LAYOUT**

(MGS installation at roadside fixed object or objects With a 31" in-line end treatment and a 31" flared end treatment at the ends of railing) See Note 8

**NOTES:**

- Line post, blocks and hardware to be used are shown on Revised Standard Plans RSP A77L1, RSP A77L2, RSP A77M1, RSP A77N1 and RSP A77N2.
- MGS post spacing to be 6'-3" center to center, except as otherwise noted.
- Except as noted, line posts are 6" x 8" x 6'-0" wood with 6" x 12" x 1'-2" wood blocks, W6 x 8.5 or W6 x 9 steel posts, 6'-0" in length, with 6" x 12" x 1'-2" notched wood blocks or notched recycled plastic blocks may be used for 6" x 8" x 6'-0" wood posts with 6" x 12" x 1'-2" wood blocks where applicable and when specified.
- A 4'-0" minimum clearance is required between the face of the railing and the face of a fixed object located directly behind MGS sections with post spacing at 6'-3". Construct MGS as shown in the detail "Strengthened Midwest Guardrail System Sections for Fixed Objects" on this plan, where the clearance between the face of the railing and the face of a fixed object is less than 4'-0", but not less than 3'-0". Where the clearance is less than 3'-0", a concrete wall or barrier should be constructed to shield the fixed object(s).

- 31" in-line terminal system end treatments are used where site conditions will not accommodate a 31" flared end treatment.
- The type of 31" terminal system to be used will be shown on the Project Plans.
- As site conditions dictate, construct additional MGS to shield fixed object(s). Additional MGS length equal to multiples of 12'-6". Post spacing at 6'-3", except as specified in Note 4.
- Layout Types 16D through 16L, shown on the A77R Series of Standard Plans, are typically used where MGS is recommended to shield roadside fixed object(s) and a crashworthy 31" end treatment is required for both directions of traffic.
- Where placement of dike is required with guard railing, see Revised Standard Plan RSP A77N4 for dike positioning details.
- The 15:1 or flatter flare for the buried post anchor is based on the edge of the paved shoulder or offset line of edge of the traveled way. The length of MGS within the 15:1 or flatter flare is based on site conditions and should be a length equal to multiples of 12'-6".

- For details of Buried Post End Anchor, see Revised Standard Plan RSP A77T2.
- For typical flare offsets for 25'-0" length parabola with maximum offset of 1'-0", see Revised Standard Plan RSP A77P1.
- W6 x 15 steel post, 8'-0" in length, with 8" x 12" x 1'-2" notched wood block or notched recycled plastic blocks may be used in place of the 10" x 10" x 8'-0" wood post with 8" x 12" x 1'-2" wood block shown in the detail "Strengthened Midwest Guardrail System Sections for Fixed Object".

**MIDWEST GUARDRAIL SYSTEM TYPICAL LAYOUTS FOR ROADSIDE FIXED OBJECTS**

NO SCALE

RSP A77R7 DATED JULY 19, 2013 SUPPLEMENTS THE STANDARD PLANS BOOK DATED 2010.

**REVISED STANDARD PLAN RSP A77R7**

2010 REVISED STANDARD PLAN RSP A77R7


Dist	COUNTY	ROUTE	POST MILES TOTAL PROJECT	SHEET No.	TOTAL SHEETS
07	LA	110	8.6/14.0	102	121

**Randell D. Hiatt**  
REGISTERED CIVIL ENGINEER

July 19, 2013  
PLANS APPROVAL DATE


THE STATE OF CALIFORNIA OR ITS OFFICERS OR AGENTS SHALL NOT BE RESPONSIBLE FOR THE ACCURACY OR COMPLETENESS OF SCANNED COPIES OF THIS PLAN SHEET.

REGISTERED PROFESSIONAL ENGINEER  
No. C50200  
Exp. 6-30-15  
CIVIL  
STATE OF CALIFORNIA

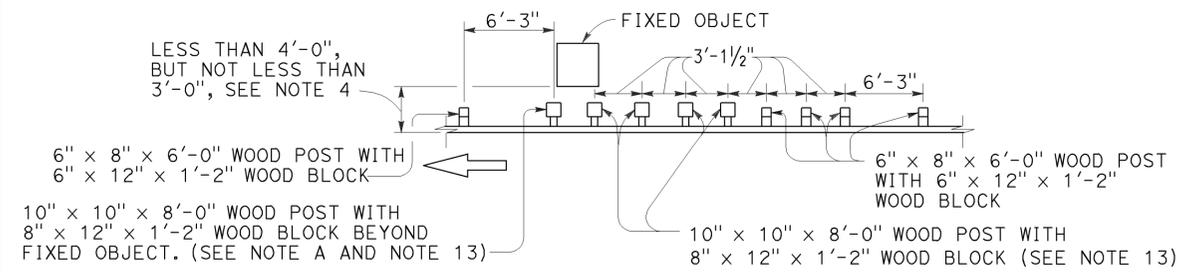


**NOTE A:** For a series of fixed objects (bridge columns, overhead sign supports, etc.) additional 10" x 10" x 8'-0" wood post with 8" x 12" x 1'-2" wood blocks at 3'-1/2" center to center spacing are to be used between fixed object(s).

### STRENGTHENED MIDWEST GUARDRAIL SYSTEM SECTIONS FOR FIXED OBJECT

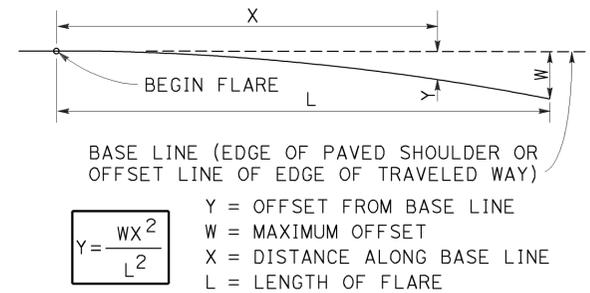


### PARABOLIC FLARE OFFSETS

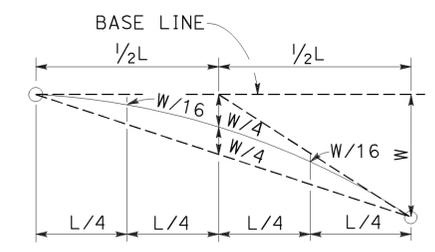


### TYPICAL PARABOLIC LAYOUT

Use strengthened MGS sections with layout Types 16K or 16L layouts where minimum clearance between the face of the MGS and fixed object(s) is less than 4'-0", but not less than 3'-0". See Note 4.

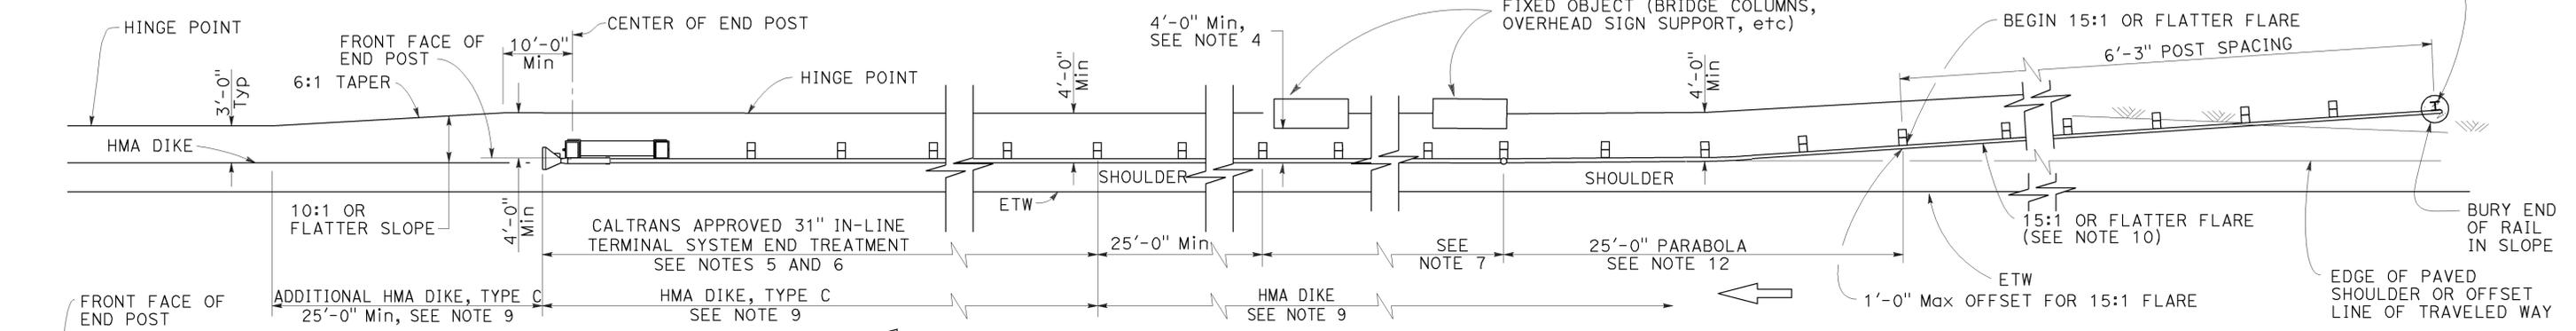

### TYPE 16K LAYOUT

(MGS installation at roadside fixed object or objects with a buried end anchor treatment and a 31" in-line end treatment at the ends of railing) See Note 8

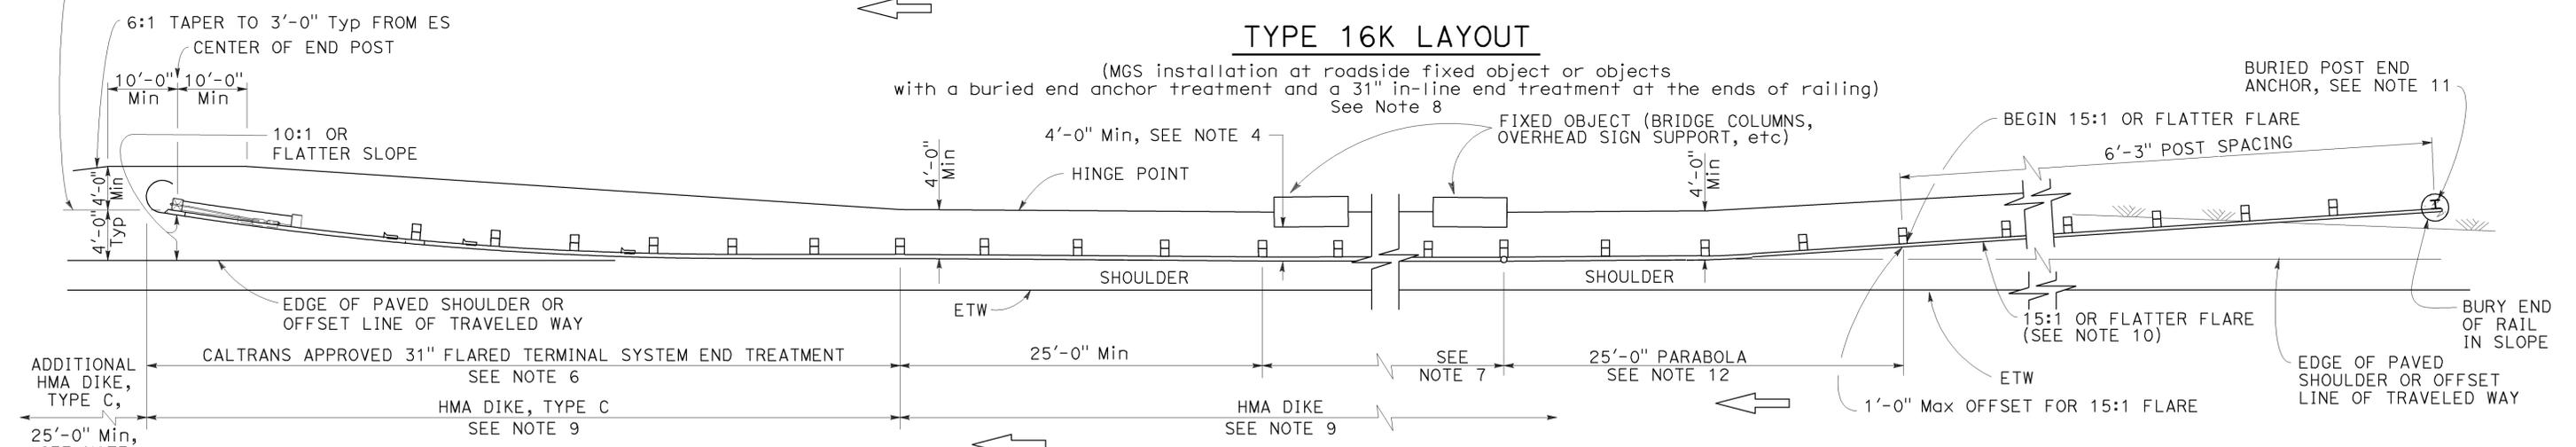

### TYPE 16L LAYOUT

(MGS installation at roadside fixed object or objects with a buried end anchor treatment and a 31" flared end treatment at the ends of railing) See Note 8

### NOTES:

- Line post, blocks and hardware to be used are shown on Revised Standard Plans RSP A77L1, RSP A77L2, RSP A77M1, RSP A77N1 and RSP A77N2.
- MGS post spacing to be 6'-3" center to center, except as otherwise noted.
- Except as noted, line posts are 6" x 8" x 6'-0" wood with 6" x 12" x 1'-2" wood blocks. W6 x 8.5 or W6 x 9 steel posts, 6'-0" in length, with 6" x 12" x 1'-2" notched wood blocks or notched recycled plastic blocks may be used for 6" x 8" x 6'-0" wood posts with 6" x 12" x 1'-2" wood blocks where applicable and when specified.
- A 4'-0" minimum clearance is required between the face of the railing and the face of a fixed object located directly behind MGS sections with post spacing at 6'-3". Construct MGS as shown in the detail "Strengthened Midwest Guardrail System Sections for Fixed Objects" on this plan, where the clearance between the face of the railing and the face of a fixed object is less than 4'-0", but not less than 3'-0". Where the clearance is less than 3'-0", a concrete wall or barrier should be constructed to shield the fixed object(s).

- 31" in-line terminal system end treatments are used where site conditions will not accommodate a 31" flared end treatment.
- The type of 31" terminal system to be used will be shown on the Project Plans.
- As site conditions dictate, construct additional MGS to shield fixed object(s). Additional MGS length equal to multiples of 12'-6". Post spacing at 6'-3", except as specified in Note 4.
- Layout Types 16D through 16L, shown on the A77R Series of Standard Plans are typically used where MGS is recommended to shield roadside fixed object(s) and a crashworthy 31" end treatment is required for both directions of traffic.
- Where placement of dike is required with MGS, see Revised Standard Plan RSP A77N4 for dike positioning details.
- The 15:1 or flatter flare for the buried post anchor is based on the edge of the paved shoulder or offset line of edge of the traveled way. The length of MGS within the 15:1 or flatter flare is based on site conditions and should be a length equal to multiples of 12'-6".

- For details of Buried Post End Anchor, see Revised Standard Plan RSP A77T2.
- For typical flare offsets for 25'-0" length parabola with maximum offset of 1'-0", see Revised Standard Plan RSP A77P1.
- W6 x 15 steel post, 8'-0" in length, with 8" x 12" x 1'-2" notched wood block or notched recycled plastic blocks may be used in place of the 10" x 10" x 8'-0" wood post with 8" x 12" x 1'-2" wood block shown in the detail "Strengthened Midwest Guardrail System Sections for Fixed Object".

STATE OF CALIFORNIA  
DEPARTMENT OF TRANSPORTATION

## MIDWEST GUARDRAIL SYSTEM TYPICAL LAYOUTS FOR ROADSIDE FIXED OBJECTS

NO SCALE

RSP A77R8 DATED JULY 19, 2013 SUPPLEMENTS THE STANDARD PLANS BOOK DATED 2010.

### REVISED STANDARD PLAN RSP A77R8

2010 REVISED STANDARD PLAN RSP A77R8


Dist	COUNTY	ROUTE	POST MILES TOTAL PROJECT	SHEET No.	TOTAL SHEETS
07	LA	110	8.6/14.0	103	121

*Randell D. Hiatt*  
REGISTERED CIVIL ENGINEER


November 15, 2013  
PLANS APPROVAL DATE

THE STATE OF CALIFORNIA OR ITS OFFICERS OR AGENTS SHALL NOT BE RESPONSIBLE FOR THE ACCURACY OR COMPLETENESS OF SCANNED COPIES OF THIS PLAN SHEET.


TO ACCOMPANY PLANS DATED 5-26-15

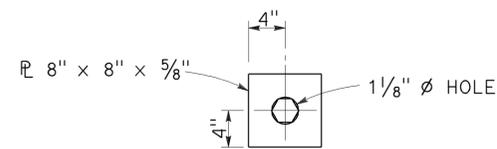


**DETAIL "A"**  
**CABLE CONNECTION**  
**END PLATE**

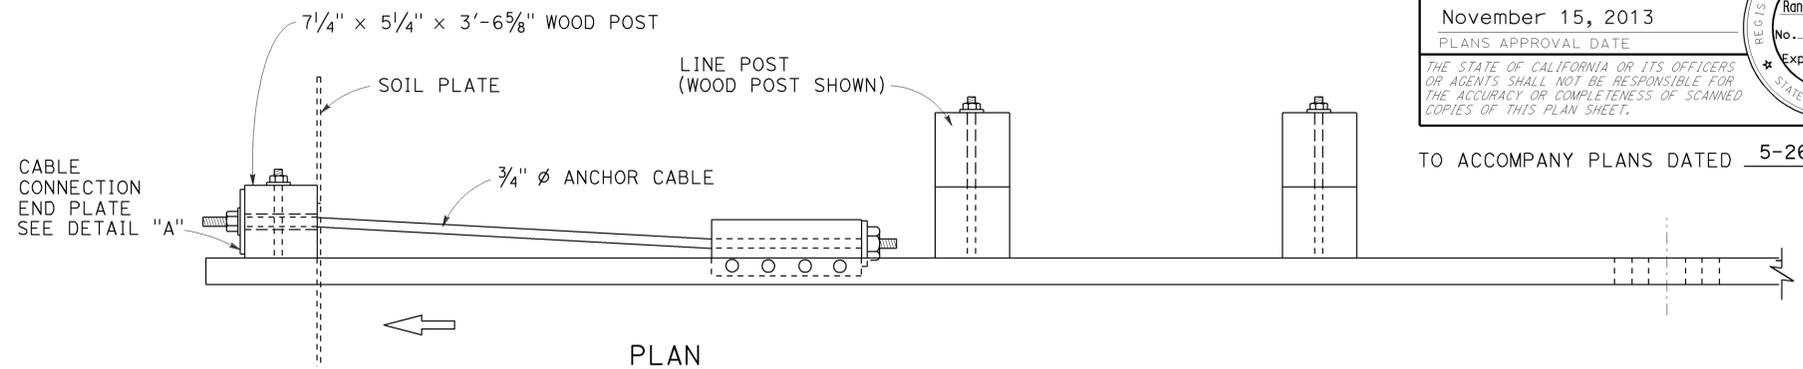

**PLAN**

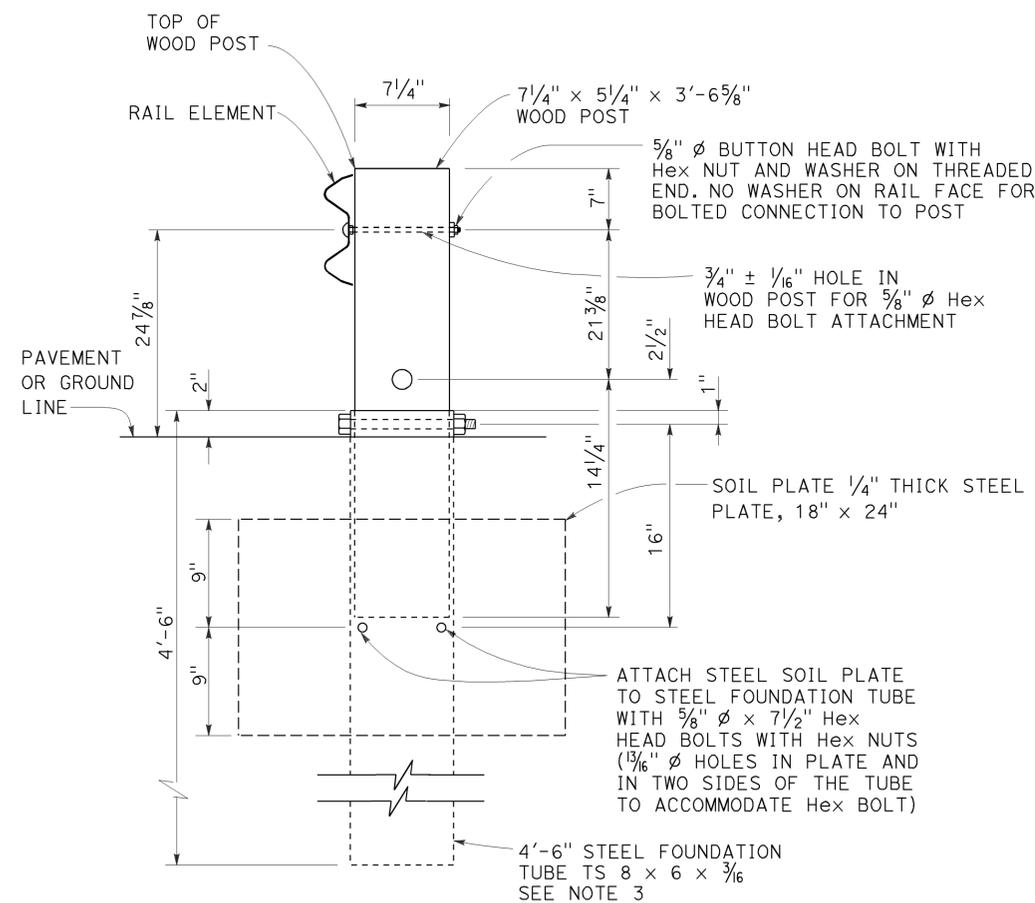

**SECTION A-A**

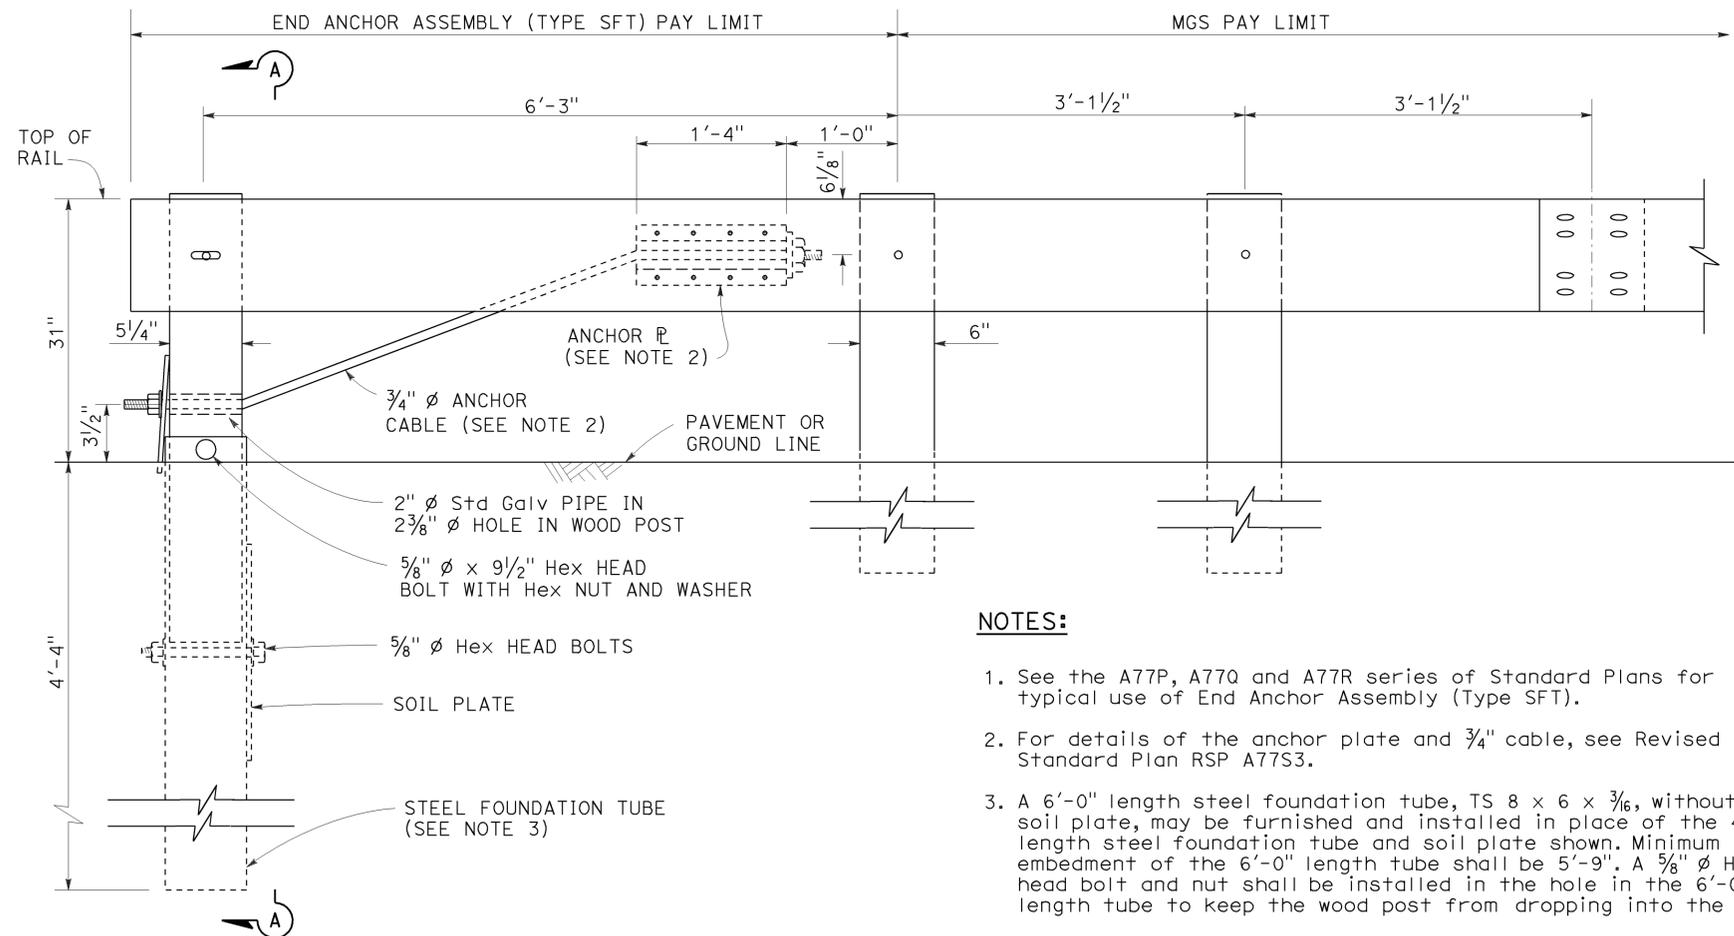

**ELEVATION**

**END ANCHOR**  
**ASSEMBLY (TYPE SFT)**

See Note 1

**NOTES:**

1. See the A77P, A77Q and A77R series of Standard Plans for typical use of End Anchor Assembly (Type SFT).
2. For details of the anchor plate and 3/4" cable, see Revised Standard Plan RSP A77S3.
3. A 6'-0" length steel foundation tube, TS 8 x 6 x 3/16, without a soil plate, may be furnished and installed in place of the 4'-6" length steel foundation tube and soil plate shown. Minimum embedment of the 6'-0" length tube shall be 5'-9". A 5/8" diameter hex head bolt and nut shall be installed in the hole in the 6'-0" length tube to keep the wood post from dropping into the tube.
4. Install line post, steel foundation tube and soil plate in soil.

STATE OF CALIFORNIA  
DEPARTMENT OF TRANSPORTATION

**MIDWEST GUARDRAIL SYSTEM**  
**END ANCHOR ASSEMBLY**  
**(TYPE SFT)**

NO SCALE

RSP A77S1 DATED NOVEMBER 15, 2013 SUPERSEDES RSP A77S1  
DATED JULY 19, 2013 THAT SUPPLEMENTS THE STANDARD PLANS BOOK DATED 2010.

**REVISED STANDARD PLAN RSP A77S1**


2010 REVISED STANDARD PLAN RSP A77S1

Dist	COUNTY	ROUTE	POST MILES TOTAL PROJECT	SHEET No.	TOTAL SHEETS
07	LA	110	8.6/14.0	104	121


*Randell D. Hiatt*  
REGISTERED CIVIL ENGINEER

July 19, 2013  
PLANS APPROVAL DATE

THE STATE OF CALIFORNIA OR ITS OFFICERS OR AGENTS SHALL NOT BE RESPONSIBLE FOR THE ACCURACY OR COMPLETENESS OF SCANNED COPIES OF THIS PLAN SHEET.


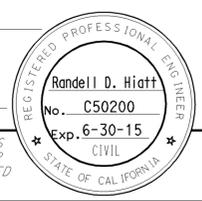


TO ACCOMPANY PLANS DATED 5-26-15

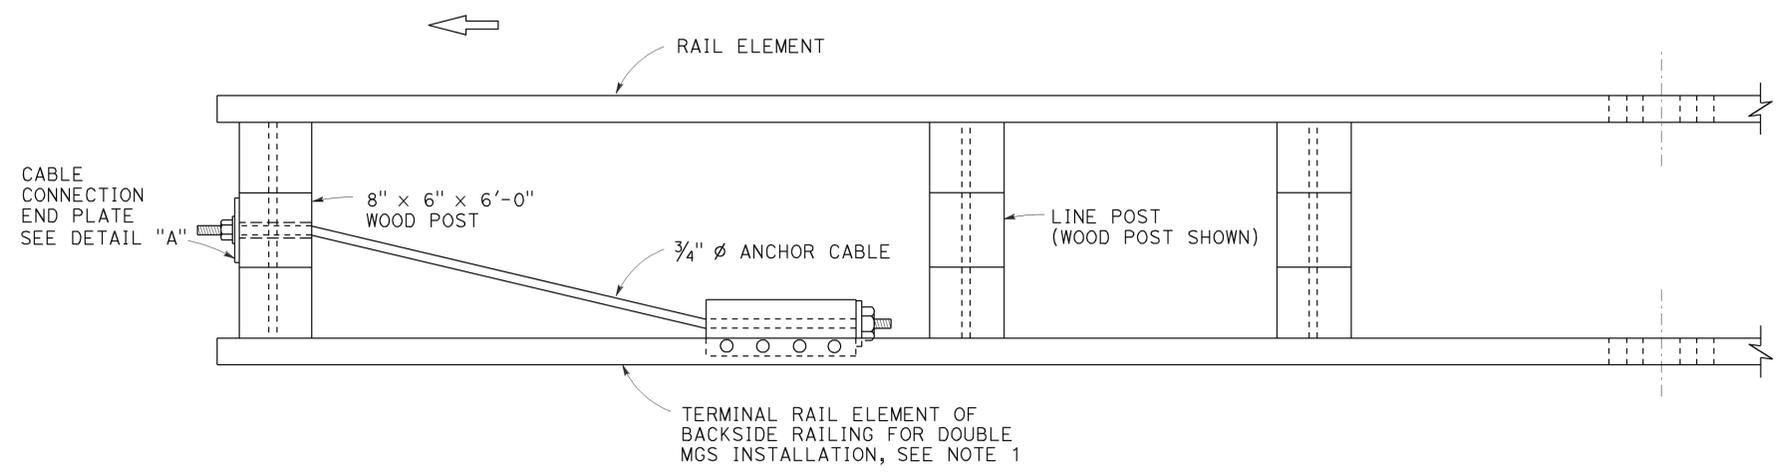

**NOTES:**

1. See Revised Standard Plans RSP A77Q3 and RSP A77R1 for typical use of rail tensioning assembly.
2. For details of the anchor plate and 3/4" cable, see Revised Standard Plan RSP A77S3.

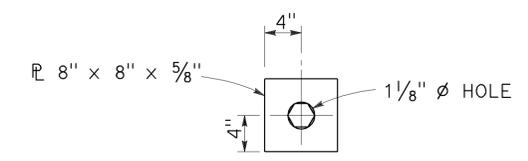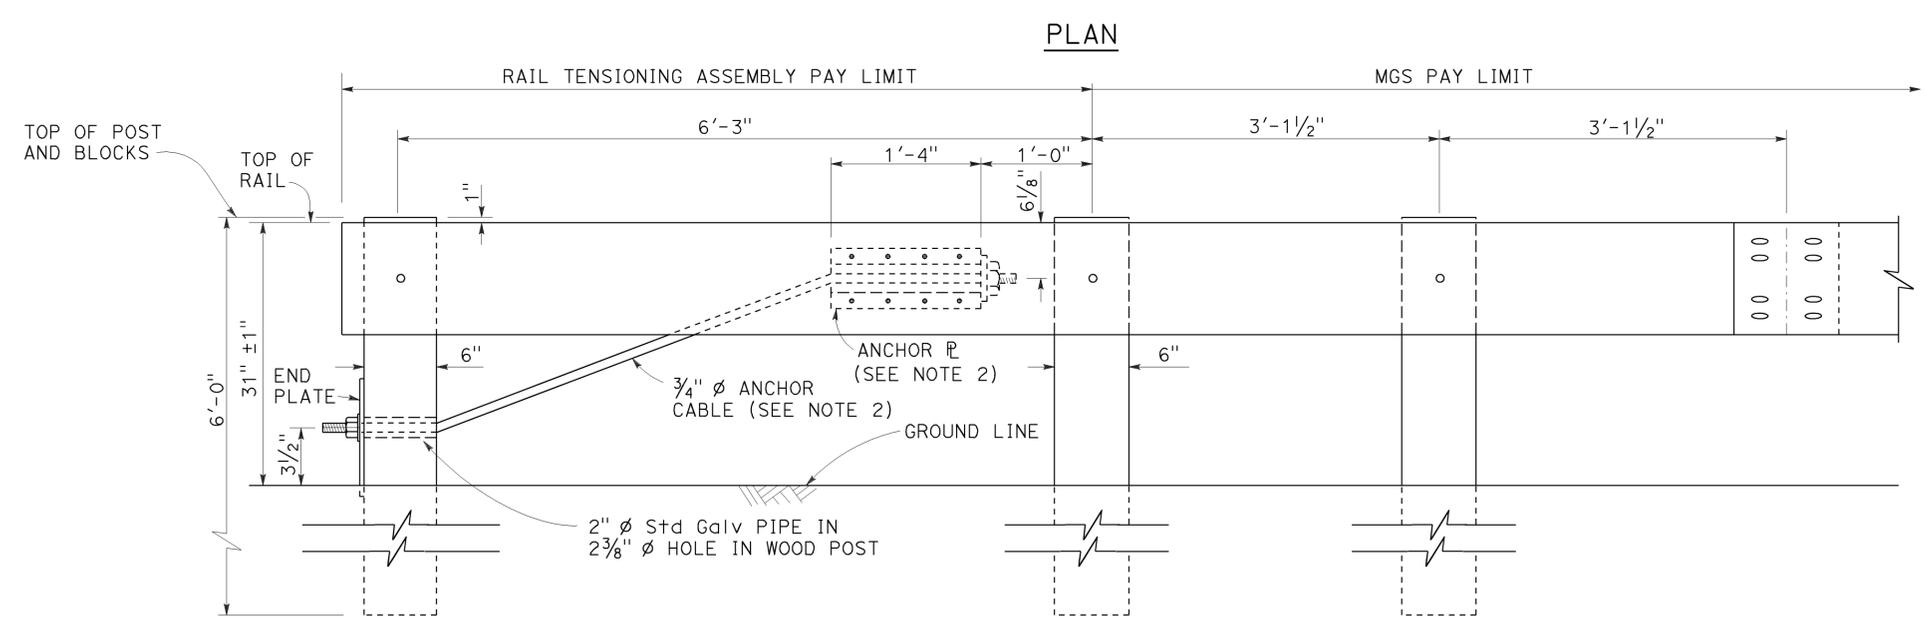

**DETAIL "A"**  
**CABLE CONNECTION**  
**END PLATE**

**ELEVATION**  
**RAIL TENSIONING**  
**ASSEMBLY**  
See Note 1

STATE OF CALIFORNIA  
DEPARTMENT OF TRANSPORTATION

**MIDWEST GUARDRAIL SYSTEM**  
**RAIL TENSIONING ASSEMBLY**

NO SCALE

RSP A77S2 DATED JULY 19, 2013 SUPPLEMENTS THE STANDARD PLANS BOOK DATED 2010.

**REVISED STANDARD PLAN RSP A77S2**

2010 REVISED STANDARD PLAN RSP A77S2

Dist	COUNTY	ROUTE	POST MILES TOTAL PROJECT	SHEET No.	TOTAL SHEETS
07	LA	110	8.6/14.0	105	121

Randell D. Hiatt  
REGISTERED CIVIL ENGINEER


November 15, 2013  
PLANS APPROVAL DATE

THE STATE OF CALIFORNIA OR ITS OFFICERS OR AGENTS SHALL NOT BE RESPONSIBLE FOR THE ACCURACY OR COMPLETENESS OF SCANNED COPIES OF THIS PLAN SHEET.


REGISTERED PROFESSIONAL ENGINEER  
Randell D. Hiatt  
No. C50200  
Exp. 6-30-15  
CIVIL  
STATE OF CALIFORNIA

TO ACCOMPANY PLANS DATED 5-26-15

**NOTE:**  
See Revised Standard Plans RSP A77S1, RSP A77S2 and RSP A77T1 for typical use of anchor cable and anchor plate.

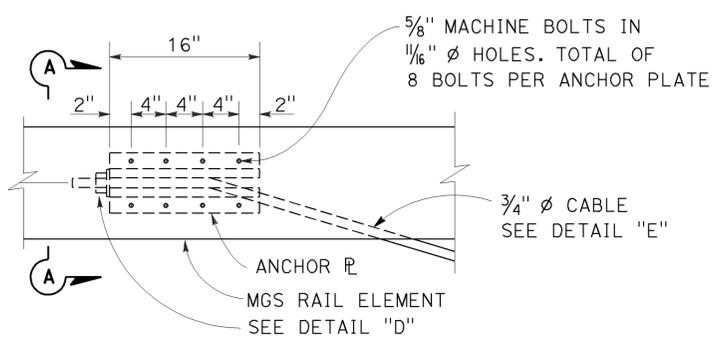


**ANCHOR PLATE DETAIL**  
(MGS shown, TBB similar)

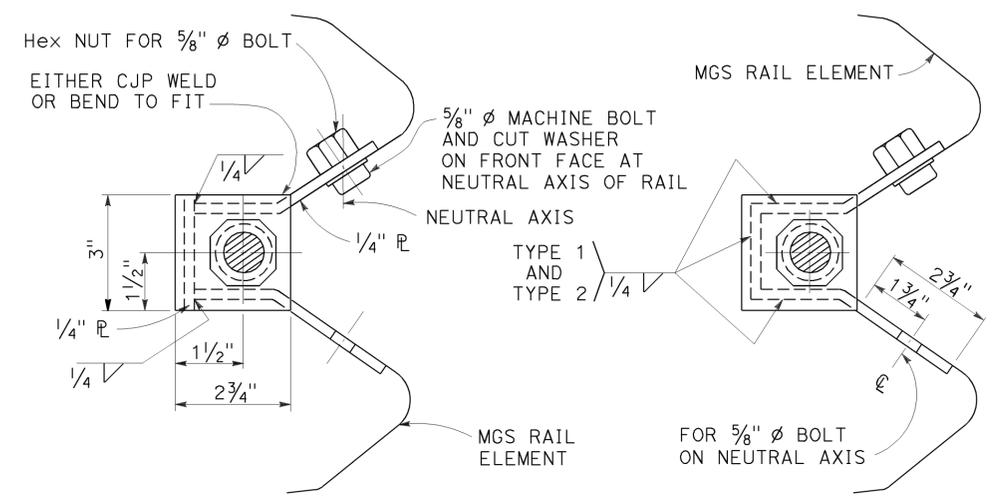


**SECTION A-A (ALTERNATIVE TYPE 1)**

**SECTION A-A (ALTERNATIVE TYPE 2)**

**NOTE:**  
Dimensioning applies to both types.

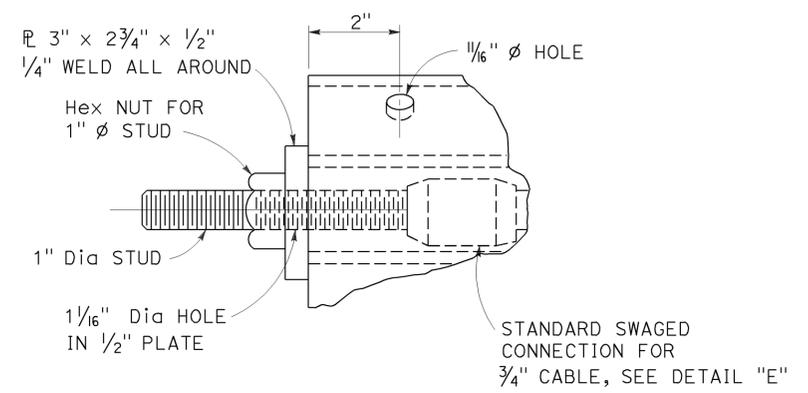

**DETAIL "D"**

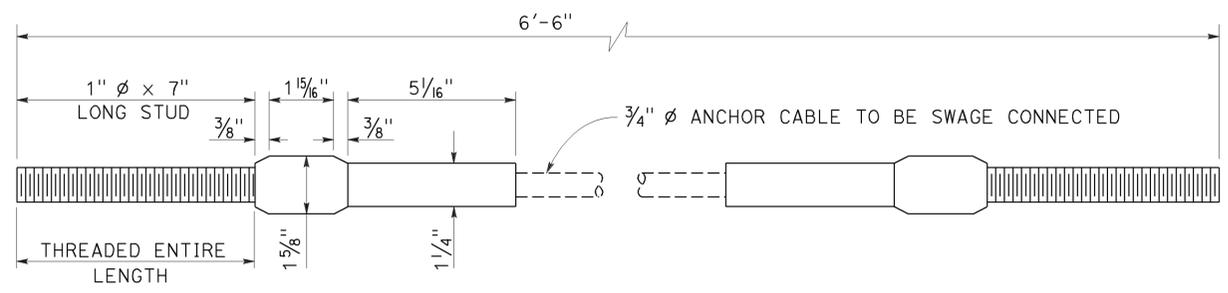

**ANCHOR CABLE WITH SWAGED FITTING AND STUD**  
**DETAIL "E"**

STATE OF CALIFORNIA  
DEPARTMENT OF TRANSPORTATION

**METAL RAILING  
ANCHOR CABLE AND  
ANCHOR PLATE DETAILS**

NO SCALE

RSP A77S3 DATED NOVEMBER 15, 2013 SUPERSEDES RSP A77S3 DATED JULY 19, 2013 THAT SUPPLEMENTS THE STANDARD PLANS BOOK DATED 2010.

2010 REVISED STANDARD PLAN RSP A77S3

**LEGEND:**

<b>AB</b>	ABANDON. IF APPLIED TO CONDUIT, REMOVE CONDUCTORS
<b>BC</b>	INSTALL PULL BOX IN EXISTING CONDUIT RUN
<b>BP</b>	PEDESTRIAN BARRICADE, TYPE AS INDICATED ON PLAN
<b>CB</b>	INSTALL CONDUIT INTO EXISTING PULL BOX
<b>CC</b>	CONNECT NEW AND EXISTING CONDUIT. REMOVE EXISTING CONDUCTORS AND INSTALL CONDUCTORS AS INDICATED
<b>CF</b>	CONDUIT TO REMAIN FOR FUTURE USE. REMOVE CONDUCTORS. INSTALL PULL TAPE
<b>DH</b>	DETECTOR HANDHOLE
<b>FA</b>	FOUNDATION TO BE ABANDONED
<b>IS</b>	INSTALL SIGN ON SIGNAL MAST ARM
<b>NS</b>	NO SLIP BASE ON STANDARD
<b>PEC</b>	PHOTOELECTRIC CONTROL
<b>PEU</b>	PHOTOELECTRIC UNIT
<b>RC</b>	EQUIPMENT OR MATERIAL TO BE REMOVED AND BECOME THE PROPERTY OF THE CONTRACTOR
<b>RE</b>	REMOVE ELECTROLIER, FUSES AND BALLAST. TAPE ENDS OF CONDUCTORS
<b>RL</b>	RELOCATE EQUIPMENT
<b>RR</b>	REMOVE AND REUSE EQUIPMENT
<b>RS</b>	REMOVE AND SALVAGE EQUIPMENT
<b>SC</b>	SPLICE NEW TO EXISTING CONDUCTORS
<b>SD</b>	SERVICE DISCONNECT
<b>TSP</b>	TELEPHONE SERVICE POINT

**ABBREVIATIONS**

APS	ACCESSIBLE PEDESTRIAN SIGNAL	M/M	MULTIPLE TO MULTIPLE TRANSFORMER
BBS	BATTERY BACKUP SYSTEM	Mtg	MOUNTING
BC	BOLT CIRCLE	MV	MERCURY VAPOR LIGHTING FIXTURE
BPB	BICYCLE PUSH BUTTON	MVDS	MICROWAVE VEHICLE DETECTION SYSTEM
C	CONDUIT	N	NEUTRAL (GROUNDED CONDUCTOR)
CB	CIRCUIT BREAKER	NB	NEUTRAL BUS
CCTV	CLOSED CIRCUIT TELEVISION	NC	NORMALLY CLOSE
Ck+	CIRCUIT	NO	NORMALLY OPEN
CMS	CHANGEABLE MESSAGE SIGN	P	CIRCUIT BREAKER'S POLE
Ctid	CALTRANS IDENTIFICATION	PB	PULL BOX
Comm	COMMUNICATION	PBA	PUSH BUTTON ASSEMBLY
DLC	LOOP DETECTOR LEAD-IN CABLE	PEC	PHOTOELECTRIC CONTROL
EMS	EXTINGUISHABLE MESSAGE SIGN	Ped	PEDESTRIAN
EVUC	EMERGENCY VEHICLE UNIT CABLE	PEU	PHOTOELECTRIC UNIT
EVUD	EMERGENCY VEHICLE UNIT DETECTOR	PT	CONDUIT WITH PULL TAPE
FB	FLASHING BEACON	RE	RELOCATED EQUIPMENT
FBCA	FLASHING BEACON CONTROL ASSEMBLY	RM	RAMP METERING
FBS	FLASHING BEACON WITH SLIP BASE	RWIS	ROADSIDE WEATHER INFORMATION SYSTEM
FO	FIBER OPTIC	SB	SLIP BASE
G	EQUIPMENT GROUNDING CONDUCTOR	SIC	SIGNAL INTERCONNECT CABLE
GB	GROUND BUS	Sig	SIGNAL
GFCI	GROUND FAULT CIRCUIT INTERRUPTER	SMA	SIGNAL MAST ARM
HAR	HIGHWAY ADVISORY RADIO	SNS	STREET NAME SIGN
Hex	HEXAGONAL	SP	SERVICE POINT
HPS	HIGH PRESSURE SODIUM	TDC	TELEPHONE DEMARCATION CABINET
IISNS	INTERNALLY ILLUMINATED STREET NAME SIGN	TMS	TRAFFIC MONITORING STATION
ISL	INDUCTION SIGN LIGHTING	TOS	TRAFFIC OPERATIONS SYSTEM
LED	LIGHT EMITTING DIODE	Veh	VEHICLE
LMA	LUMINAIRE MAST ARM	VIVDS	VIDEO IMAGE VEHICLE DETECTION SYSTEM
LPS	LOW PRESSURE SODIUM	WIM	WEIGH-IN-MOTION
Ltg	LIGHTING	Xfmr	TRANSFORMER
Lum	LUMINAIRE		
M	METERED		
MAT	MAST ARM MOUNTING TOP ATTACHMENT		
MAS	MAST ARM MOUNTING SIDE ATTACHMENT		

Dist	COUNTY	ROUTE	POST MILES TOTAL PROJECT	SHEET No.	TOTAL SHEETS
07	LA	110	8.6/14.0	106	121

*Theresa Gabriel*  
REGISTERED ELECTRICAL ENGINEER

July 19, 2013  
PLANS APPROVAL DATE

Theresa  
Aziz Gabriel  
No. E15129  
Exp. 6-30-14  
ELECTRICAL  
STATE OF CALIFORNIA

THE STATE OF CALIFORNIA OR ITS OFFICERS OR AGENTS SHALL NOT BE RESPONSIBLE FOR THE ACCURACY OR COMPLETENESS OF SCANNED COPIES OF THIS PLAN SHEET.

TO ACCOMPANY PLANS DATED 5-26-15

**SOFFIT AND WALL MOUNTED LUMINAIRES**

- PENDANT, 70 W HPS UNLESS OTHERWISE SPECIFIED
- FLUSH, 70 W HPS UNLESS OTHERWISE SPECIFIED
- WALL SURFACE, 70 W HPS UNLESS OTHERWISE SPECIFIED
- EXISTING SOFFIT OR WALL LUMINAIRE TO REMAIN UNMODIFIED
- EXISTING SOFFIT OR WALL LUMINAIRE TO BE MODIFIED AS SPECIFIED

**NOTE:**  
Arrow indicates "street side" of luminaire.

COMMONLY USED SYMBOLS FOR UNITED STATES CUSTOMARY UNITS OF MEASUREMENT:

SYMBOL USED	DEFINITIONS
$\Omega$	OHMS
min	MINUTE
s	SECOND
bps	BITS PER SECOND
Bps	BYTES PER SECOND
A	AMPERE
V	VOLT
V(dc)	VOLT (DIRECT CURRENT)
V(ac)	VOLT (ALTERNATING CURRENT)
FC	FOOT - CANDLE
W	WATTS
VA	VOLT-AMPERE
M	MEGA
k	KILO
m	MILLI
$\mu$	MICRO
P	PICO
HZ	HERTZ

**MISCELLANEOUS ELECTROLIERS**

NEW	EXISTING	
		LUMINAIRE ON WOOD POLE
		NON-STANDARD ELECTROLIER (SEE PROJECT NOTES OR PROJECT PLANS)
		CITY ELECTROLIER
		ELECTROLIER FOUNDATION (FUTURE INSTALLATION)

- NOTES:**
- HPS luminaires shall be 310 W HPS when installed on Type 21, 21D, 30, 31 and 32 Standards, unless otherwise specified. HPS luminaires shall be 200 W when installed on other type standards or poles, unless otherwise specified.
  - LED luminaires shall be 235 W when installed on Type 21, 21D, 30, 31 and 32 Standards, unless otherwise specified. LED luminaires shall be 165 W when installed on other type standards or poles, unless otherwise specified.
  - Luminaires shall be the cutoff type, ANSI Type III medium cutoff lighting distribution, unless otherwise specified.

**STANDARD ELECTROLIER**

NEW	EXISTING	STANDARD TYPE
		15
		15D
		15 STRUCTURE
		15D STRUCTURE
		21
		21D
		21 STRUCTURE
		21D STRUCTURE
		30
		31
		32

STATE OF CALIFORNIA  
DEPARTMENT OF TRANSPORTATION

**ELECTRICAL SYSTEMS  
(LEGEND AND ABBREVIATIONS)**

NO SCALE

RSP ES-1A DATED JULY 19, 2013 SUPERSEDES STANDARD PLAN ES-1A DATED MAY 20, 2011 - PAGE 425 OF THE STANDARD PLANS BOOK DATED 2010.

**REVISED STANDARD PLAN RSP ES-1A**

2010 REVISED STANDARD PLAN RSP ES-1A

Dist	COUNTY	ROUTE	POST MILES TOTAL PROJECT	SHEET No.	TOTAL SHEETS
07	LA	110	8.6/14.0	107	121

*Theresa Gabriel*  
REGISTERED ELECTRICAL ENGINEER

July 19, 2013  
PLANS APPROVAL DATE

Theresa  
Aziz Gabriel  
No. E15129  
Exp. 6-30-14  
ELECTRICAL  
STATE OF CALIFORNIA

THE STATE OF CALIFORNIA OR ITS OFFICERS OR AGENTS SHALL NOT BE RESPONSIBLE FOR THE ACCURACY OR COMPLETENESS OF SCANNED COPIES OF THIS PLAN SHEET.

TO ACCOMPANY PLANS DATED 5-26-15

**CONDUIT**

**SIGNAL EQUIPMENT**

NEW	EXISTING	
---	---	LIGHTING CONDUIT, UNLESS OTHERWISE INDICATED OR NOTED
---	---	TRAFFIC SIGNAL CONDUIT
---C---	---c---	COMMUNICATION CONDUIT
---T---	---t---	TELEPHONE CONDUIT
---F---	---f---	FIRE ALARM CONDUIT
---FO---	---fo---	FIBER OPTIC CONDUIT
---	---	CONDUIT TERMINATION
		CONDUIT RISER ATTACHED TO THE STRUCTURE OR SERVICE POLE

NEW	EXISTING	
		PEDESTRIAN SIGNAL HEAD "C" INDICATES COUNTDOWN PEDESTRIAN HEAD
		PUSH BUTTON ASSEMBLY POST
		PEDESTRIAN BARRICADE
		VEHICLE SIGNAL HEAD (WITH BACKPLATE AND 3-SECTIONS: RED, YELLOW AND GREEN)
		VEHICLE SIGNAL HEAD WITH ANGLE VISOR
		MODIFICATIONS OF BASIC SYMBOL: "L" INDICATES ALL NON-ARROW SECTIONS LOUVERED "LG" INDICATES LOUVERED GREEN SECTION ONLY "PV" INDICATES ALL 12" SECTIONS PROGRAMMED VISIBILITY "8" INDICATES ALL 8" SECTIONS (ONLY WHEN SPECIFIED)

**SIGNAL EQUIPMENT Cont**

NEW	EXISTING	
		GUARD POST
		TYPE 1 STANDARD WITH RAMP METERING SIGN
		OPTICAL DETECTOR FOR THE EMERGENCY VEHICLE DETECTION SYSTEM

**SERVICE EQUIPMENT**

 
NEW	EXISTING	
---OH---	---oh---	OVERHEAD LINES
		WOOD POLE, "U" INDICATES UTILITY OWNED
		POLE GUY WITH ANCHOR
		UTILITY TRANSFORMER - GROUND MOUNTED
		SERVICE EQUIPMENT ENCLOSURE TYPE. DOOR INDICATES FRONT OF ENCLOSURE
		TELEPHONE DEMARCATION CABINET

NEW	EXISTING	
		VEHICLE SIGNAL HEAD CONSISTING OF RED, YELLOW AND GREEN LEFT ARROW SECTIONS
		VEHICLE SIGNAL HEAD CONSISTING OF RED AND YELLOW SECTIONS WITH AN UP GREEN ARROW SECTION
		VEHICLE SIGNAL HEAD (5 SECTION) CONSISTING OF RED, YELLOW AND GREEN SECTIONS WITH YELLOW AND GREEN RIGHT ARROW SECTIONS
		TYPE 15TS STANDARD WITH VEHICLE SIGNAL HEAD AND LUMINAIRE
		TYPE 21TS STANDARD WITH VEHICLE SIGNAL HEAD AND LUMINAIRE
		STANDARD WITH LUMINAIRE AND SIGNAL MAST ARMS AND ATTACHED VEHICLE SIGNAL HEADS
		TYPE 1 STANDARD WITH ATTACHED VEHICLE SIGNAL HEADS
		STANDARD WITH A SIGNAL MAST ARM, ATTACHED VEHICLE SIGNAL HEADS AND INTERNALLY ILLUMINATED STREET NAME SIGN
		CONTROLLER ASSEMBLY. DOOR INDICATES FRONT OF CABINET

**NOTES:**

- All signal sections shall be 12" unless shown otherwise.
- Signal heads shall be provided with backplates unless shown otherwise.

**POLE-MOUNTED SERVICE DESIGNATION**



**FLASHING BEACON**

NEW	EXISTING	
		FLASHING BEACON (ONE VEHICLE SIGNAL HEAD WITH BACKPLATE AND VISOR) "R" INDICATES RED INDICATION, "Y" INDICATES YELLOW INDICATION
		FLASHING BEACON WITH TYPE 15-FBS STANDARD AND A SIGN.
		FLASHING BEACON WITH TYPES 9, 9A OR 9B SIGN UNLESS OTHERWISE SPECIFIED OR INDICATED

**ILLUMINATED OVERHEAD SIGN**


NEW	EXISTING	
		SINGLE POST, SINGLE ILLUMINATED SIGN, BALANCED BUTTERFLY
		SINGLE POST, DOUBLE ILLUMINATED SIGN, BALANCED BUTTERFLY
		SINGLE POST, SINGLE ILLUMINATED SIGN, FULL CANTILEVER
		DOUBLE POST, SINGLE ILLUMINATED SIGN
		SINGLE ILLUMINATED SIGN MOUNTED ON STRUCTURE
		DOUBLE POST, SINGLE ILLUMINATED SIGN WITH ELECTROLIER

STATE OF CALIFORNIA  
DEPARTMENT OF TRANSPORTATION  
**ELECTRICAL SYSTEMS  
(LEGEND AND ABBREVIATIONS)**

NO SCALE  
RSP ES-1B DATED JULY 19, 2013 SUPERSEDES STANDARD PLAN ES-1B DATED MAY 20, 2011 - PAGE 426 OF THE STANDARD PLANS BOOK DATED 2010.

**REVISED STANDARD PLAN RSP ES-1B**


2010 REVISED STANDARD PLAN RSP ES-1B

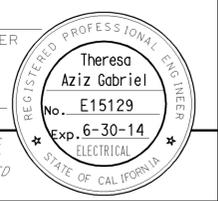


TO ACCOMPANY PLANS DATED 5-26-15

### EQUIPMENT IDENTIFICATION


#### ILLUMINATED SIGN IDENTIFICATION NUMBER:

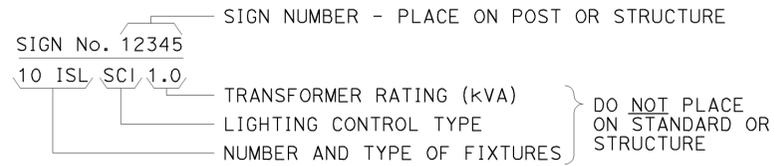


#### ELECTROLIER OR EQUIPMENT IDENTIFICATION NUMBER:

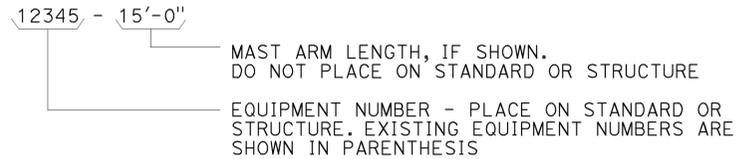


#### CONDUIT AND CONDUCTOR IDENTIFICATION:

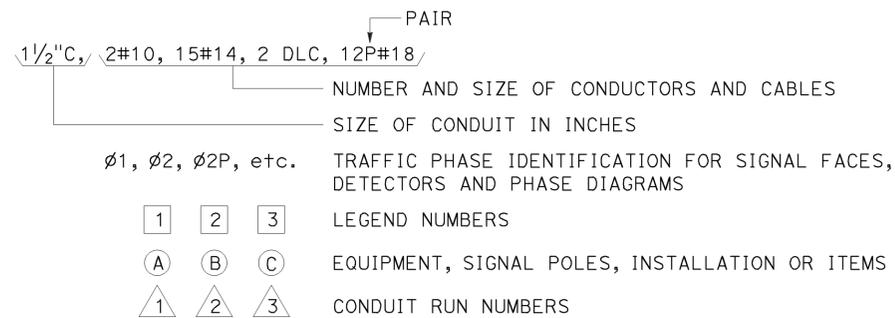


#### SIGNAL AND LIGHTING STANDARD (TYPICAL DESIGNATION):

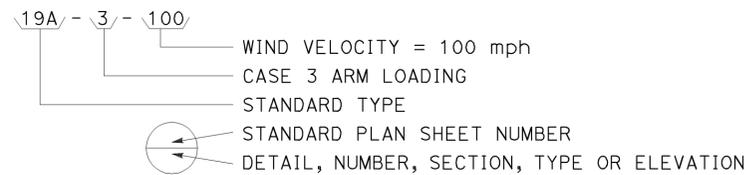


### MISCELLANEOUS EQUIPMENT

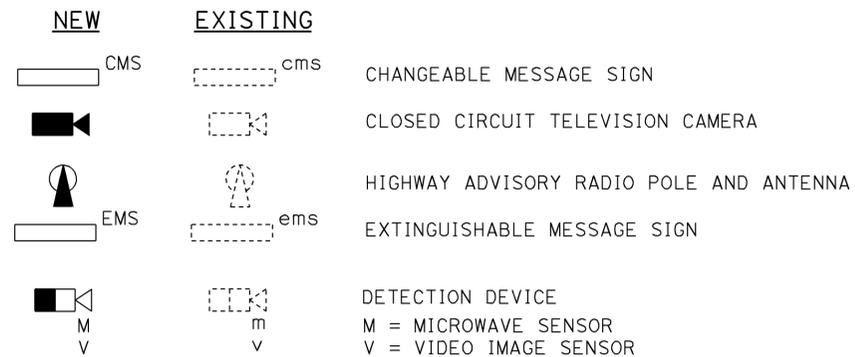



### WIRING DIAGRAM LEGEND

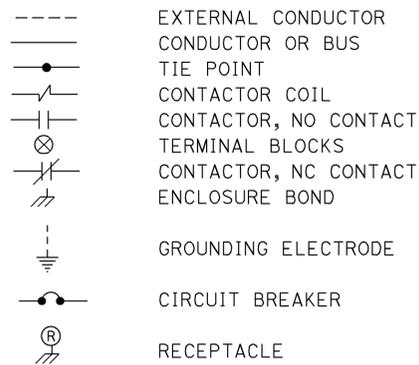

### PULL BOXES

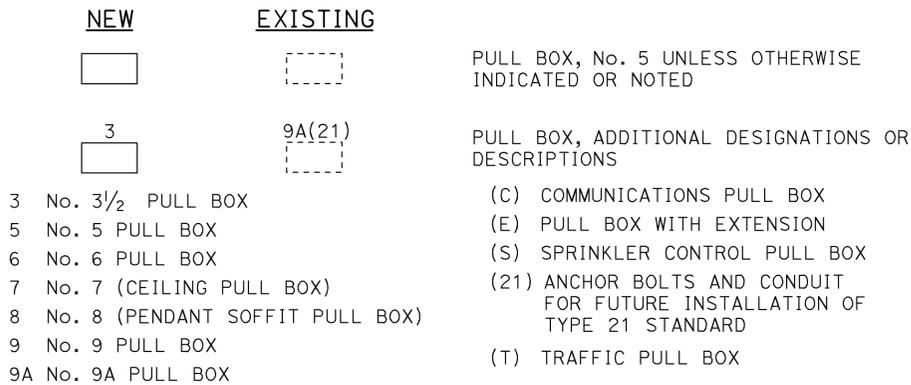

### VEHICLE DETECTORS

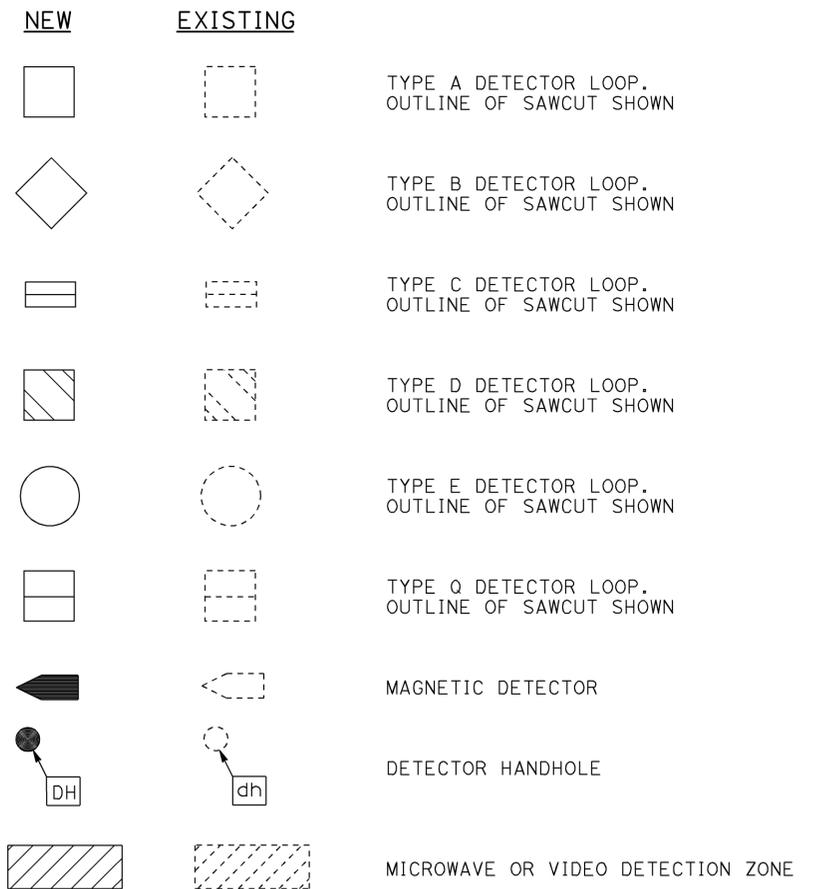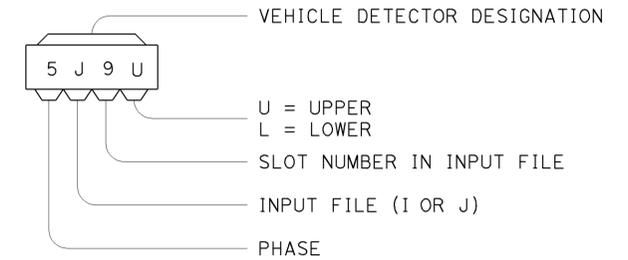

STATE OF CALIFORNIA  
 DEPARTMENT OF TRANSPORTATION

## ELECTRICAL SYSTEMS (LEGEND AND ABBREVIATIONS)

NO SCALE

RSP ES-1C DATED JULY 19, 2013 SUPERSEDES STANDARD PLAN ES-1C DATED MAY 20, 2011 - PAGE 427 OF THE STANDARD PLANS BOOK DATED 2010.

**REVISED STANDARD PLAN RSP ES-1C**

2010 REVISED STANDARD PLAN RSP ES-1C

DIST	COUNTY	ROUTE	POST MILES TOTAL PROJECT	SHEET NO.	TOTAL SHEETS
07	LA	110	8.6/14.0	109	121


Theresa Gabriel  
REGISTERED ELECTRICAL ENGINEER

July 19, 2013  
PLANS APPROVAL DATE


Theresa Aziz Gabriel  
No. E15129  
Exp. 6-30-14  
ELECTRICAL  
STATE OF CALIFORNIA

THE STATE OF CALIFORNIA OR ITS OFFICERS OR AGENTS SHALL NOT BE RESPONSIBLE FOR THE ACCURACY OR COMPLETENESS OF SCANNED COPIES OF THIS PLAN SHEET.


TO ACCOMPANY PLANS DATED 5-26-15

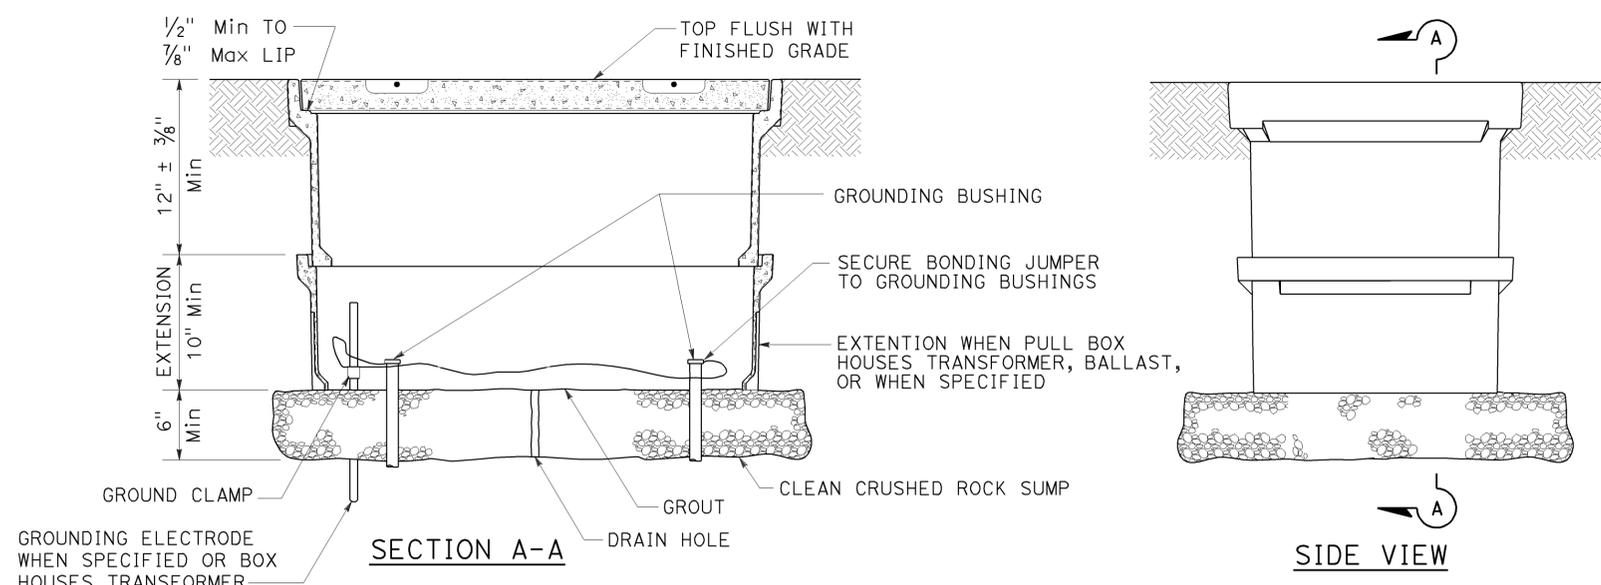


**INSTALLATION DETAILS**  
**DETAIL A**

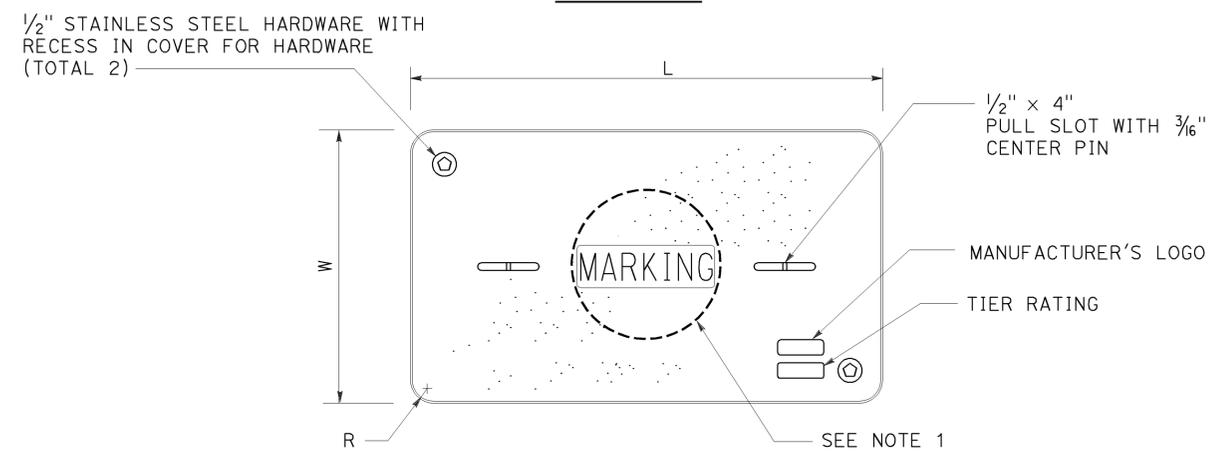

**COVER TOP VIEW**

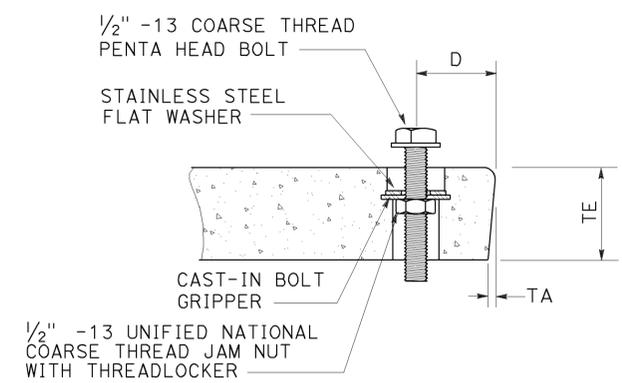

**TYPICAL COVER CAPTIVE BOLT**  
**OR SIMILAR**

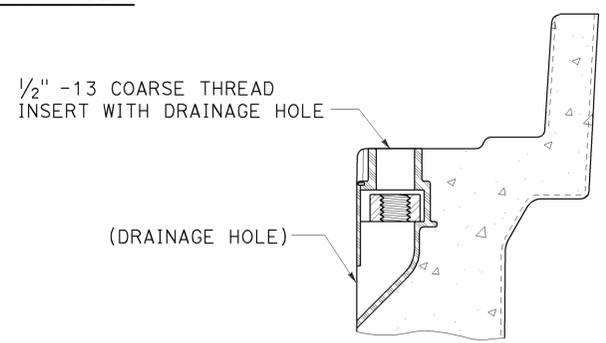

**TYPICAL THREADED INSERT**  
**OR SIMILAR**

**NOTES:**

- Pull box covers shall be marked as follows: "SERVICE" Service circuits between service point and service disconnect; "SPRINKLER-CONTROL" sprinkler control circuits, 50 V or less; "CALTRANS" on all pull boxes, except pull boxes marked "SPRINKLER-CONTROL"; and "TELEPHONE" Telephone service;
  - No. 3 1/2 pull box.
    - "SIGNAL" - Traffic signal circuits with or without lighting or sign lighting circuits.
    - "LIGHTING" - Lighting or sign lighting circuits where voltage is under 600 V.
  - No. 5, 6, 9 or 9A pull box.
    - "TRAFFIC SIGNAL" - Traffic signal circuits with or without lighting or sign lighting circuits.
    - "LIGHTING" - Lighting or sign lighting circuits where voltage is under 600 V.
    - "LIGHTING-HIGH VOLTAGE" - Lighting or sign lighting circuits where voltage is above 600 V.
    - "IRRIGATION" - Circuits to irrigation controller 120 V or more.
    - "RAMP METER" - Ramp meter circuits.
    - "COUNT STATION" - Count or speed monitor circuits.
    - "COMMUNICATIONS" - Communication circuits.
    - "TOS COMMUNICATIONS" - TOS communication line.
    - "TOS POWER" - TOS power.
    - "TDC POWER" - Telephone demarcation cabinet power.
    - "CCTV" - Closed circuit television circuits.
    - "TMS" - Traffic monitoring station circuits.
    - "CMS" - Changeable message sign circuits.
    - "HAR" - Highway advisory radio circuits.
    - "BOOSTER PUMP" - Booster pump circuit.
- The nominal dimensions of the opening in which the cover sets shall be the same as the cover dimensions except the length and width dimensions shall be 1/8" greater.
- Covers and boxes shall be interchangeable with California standard male and female gages. When interchanged with a standard male or female gage, the top surfaces shall be flush within 1/8". Top outside radius of covers and pull boxes shall have a 1/8" radius.
- Pull box extension may be another pull box as long as the bottom edge of the pull box can fit into the cover opening.
- All dimensions for the cover for non-traffic pull box are nominal values.

DIMENSION TABLE										
PULL BOX	PULL BOX			COVER						
	MINIMUM DEPTH BOX	MINIMUM DEPTH EXTENSION	MAXIMUM WEIGHT	L	W	R	TE	TA	D	MAXIMUM WEIGHT
No. 3 1/2	12"	N/A	40 lb	1' - 3 3/8"	10 1/8"	1 3/8"	2"	1/8"	1 3/4"	30 lb
No. 5	12"	10"	55 lb	1' - 11 1/4"	1' - 1 3/4"	1 3/8"	2"	1/8"	1 3/4"	60 lb
No. 6	12"	10"	70 lb	2' - 6 1/2"	1' - 5 1/2"	1 3/8"	2"	1/8"	2"	85 lb

STATE OF CALIFORNIA  
DEPARTMENT OF TRANSPORTATION  
**ELECTRICAL SYSTEMS**  
**(NON-TRAFFIC PULL BOX)**  
NO SCALE

RSP ES-8A DATED JULY 19, 2013 SUPERSEDES RSP ES-8A DATED JANUARY 20, 2012 THAT SUPPLEMENTS THE STANDARD PLANS BOOK DATED 2010.

**REVISED STANDARD PLAN RSP ES-8A**

2010 REVISED STANDARD PLAN RSP ES-8A


DIST	COUNTY	ROUTE	POST MILES TOTAL PROJECT	SHEET NO.	TOTAL SHEETS
07	LA	110	8.6/14.0	110	121

*Theresa Gabriel*  
 REGISTERED ELECTRICAL ENGINEER  
 July 19, 2013  
 PLANS APPROVAL DATE

THE STATE OF CALIFORNIA OR ITS OFFICERS OR AGENTS SHALL NOT BE RESPONSIBLE FOR THE ACCURACY OR COMPLETENESS OF SCANNED COPIES OF THIS PLAN SHEET.

REGISTERED PROFESSIONAL ENGINEER  
 Theresa Aziz Gabriel  
 No. E15129  
 Exp. 6-30-14  
 ELECTRICAL  
 STATE OF CALIFORNIA

TO ACCOMPANY PLANS DATED 5-26-15

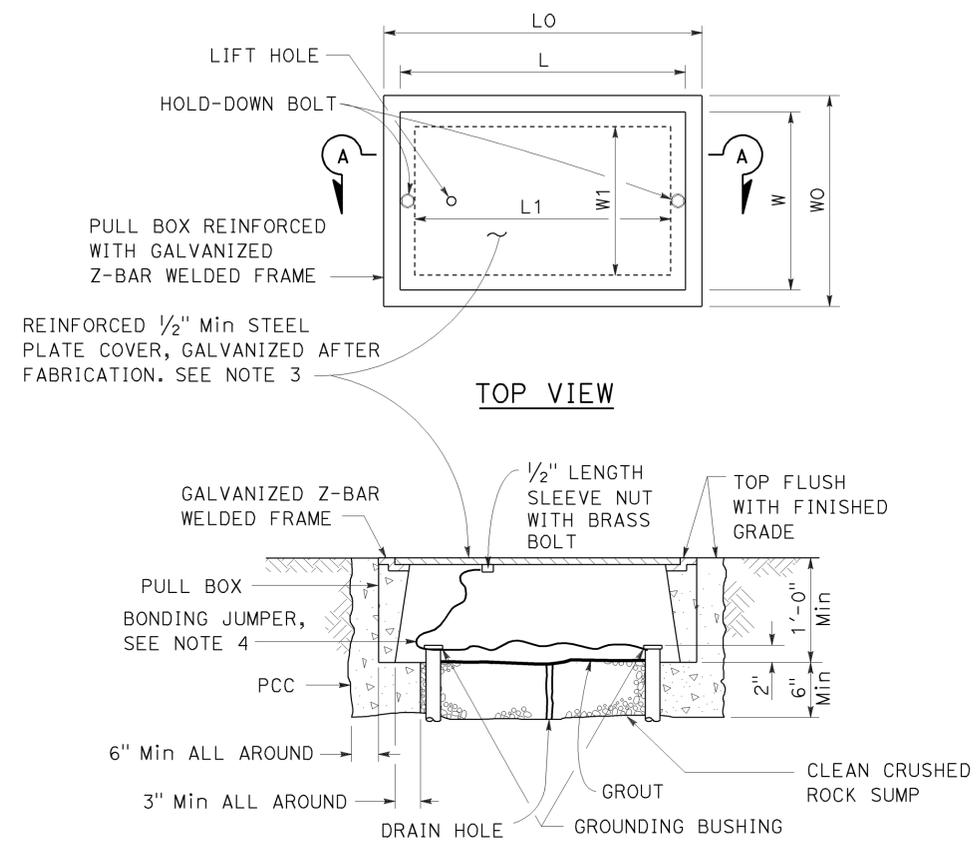

SECTION A-A  
**No. 3 1/2(T), No. 5(T) AND  
 No. 6(T) TRAFFIC PULL BOX**

**NOTES:**

- Traffic pull box shall be provided with steel cover and special concrete footing. Steel cover shall have embossed non-skid pattern.
- Steel reinforcing shall be as regularly used in the standard products of the respective manufacturer.
- Pull box covers shall be marked as follows: "SERVICE" Service circuits between service point and service disconnect; "SPRINKLER-CONTROL" Sprinkler control circuits, 50 V or less; "CALTRANS" On all pull boxes, except pull boxes marked "SPRINKLER-CONTROL"; and "TELEPHONE" Telephone service.
  - No. 3 1/2(T) pull box.
    - "SIGNAL" - Traffic signal circuits with or without lighting or sign lighting circuits.
    - "LIGHTING" - Lighting or sign lighting circuits where voltage is under 600 V.
  - No. 5(T) or 6(T) pull box.
    - "TRAFFIC SIGNAL" - Traffic signal circuits with or without lighting or sign lighting circuits.
    - "LIGHTING" - Lighting or sign lighting circuits where voltage is under 600 V.
    - "LIGHTING-HIGH VOLTAGE" - Lighting or sign lighting circuits where voltage is above 600 V.
    - "IRRIGATION" - Circuits to irrigation controller 120 V or more.
    - "RAMP METER" - Ramp meter circuits.
    - "COUNT STATION" - Count or speed monitor circuits.
    - "COMMUNICATION" - Communication circuits.
    - "TOS COMMUNICATIONS" - TOS communications line.
    - "TOS POWER" - TOS power.
    - "TDC POWER" - Telephone demarcation cabinet power.
    - "CCTV" - Closed circuit television circuits.
    - "TMS" - Traffic monitoring station circuits.
    - "CMS" - Changeable message sign circuits.
    - "HAR" - Highway advisory radio circuits.
    - "BOOSTER PUMP" - Booster pump circuit.
- Bonding jumper for metal covers shall be 3' long, minimum.
- The nominal dimensions of the opening in which the cover sets shall be the same as the cover dimensions except the length and width dimensions shall be 1/8" greater.
- Covers and boxes shall be interchangeable with California standard male and female gages. When interchanged with a standard male or female gage, the top surfaces shall be flush within 1/8".

PULL BOX	PULL BOX						COVER				
	MINIMUM * THICKNESS	MINIMUM DEPTH BOX AND EXTENSION	W0	L0	L1	W1	L **	W **	R	EDGE THICKNESS	EDGE TAPER
No. 3 1/2(T)	1 1/2"	1'-0"	1'-5"± 1"	1'-8 3/8"±	1'-2 1/2"±	10 5/8"± 1"	1'-8"±	1'-1 3/4"±	0"	1/2"	NONE
No. 5(T)	1 3/4"	1'-0"	1'-11 1/2"± 1"	2'-5 1/2"±	1'-7"±	1'-1"± 1"	2'-3"±	1'-4"±	0"	1/2"	NONE
No. 6(T)	2"	1'-0"	2'-6"± 1"	2'-11 1/2"±	1'-11 1/2"±	1'-5"± 1"	2'-9"±	1'-8"±	0"	1/2"	NONE

\* EXCLUDING CONDUIT WEB      \*\* TOP DIMENSION

STATE OF CALIFORNIA  
 DEPARTMENT OF TRANSPORTATION  
**ELECTRICAL SYSTEMS  
 (TRAFFIC PULL BOX)**  
 NO SCALE

RSP ES-8B DATED JULY 19, 2013 SUPERSEDES RSP ES-8B DATED JANUARY 20, 2012 THAT SUPPLEMENTS THE STANDARD PLANS BOOK DATED 2010.

**REVISED STANDARD PLAN RSP ES-8B**

2010 REVISED STANDARD PLAN RSP ES-8B

Dist	COUNTY	ROUTE	POST MILES TOTAL PROJECT	SHEET No.	TOTAL SHEETS
07	LA	110	8.6/14.0	111	121


Stanley P. Johnson  
 REGISTERED CIVIL ENGINEER  
 November 15, 2013  
 PLANS APPROVAL DATE  
 THE STATE OF CALIFORNIA OR ITS OFFICERS OR AGENTS SHALL NOT BE RESPONSIBLE FOR THE ACCURACY OR COMPLETENESS OF SCANNED COPIES OF THIS PLAN SHEET.

REGISTERED PROFESSIONAL ENGINEER  
 Stanley P. Johnson  
 No. C57793  
 Exp. 3-31-14  
 CIVIL  
 STATE OF CALIFORNIA


POLE TYPE	POLE DATA			BASE PLATE DATA				CIDH		
	HEIGHT "h"	Min OD		THICKNESS	"c"	THICKNESS	ANCHOR BOLT SIZE	BC = BOLT CIRCLE	Dia	"d"
		BASE	TOP							
CCTV 25	25'	7 <sup>3</sup> / <sub>8</sub> "	3 <sup>3</sup> / <sub>4</sub> "	0.1793"	1'-1"	1"	1/2" $\phi$ x 36"	11 <sup>1</sup> / <sub>2</sub> "	2'-6"	7'-0"
CCTV 30	30'	8"			1'-1 <sup>1</sup> / <sub>2</sub> "			1'-0"		7'-6"
CCTV 35	35'	8 <sup>5</sup> / <sub>8</sub> "			1'-2"			1'-1"		8'-0"
CCTV 40	40'	9 <sup>3</sup> / <sub>8</sub> "			1'-1 <sup>1</sup> / <sub>2</sub> "			1'-1 <sup>1</sup> / <sub>2</sub> "		8'-0"
CCTV 45	45'	10"			1'-3"			1'-2"		8'-6"

TO ACCOMPANY PLANS DATED 5-26-15


CCTV MOUNTING ADAPTER DETAIL SHALL BE SUBMITTED BY THE CONTRACTOR FOR THE ENGINEER'S APPROVAL, SEE DETAIL C

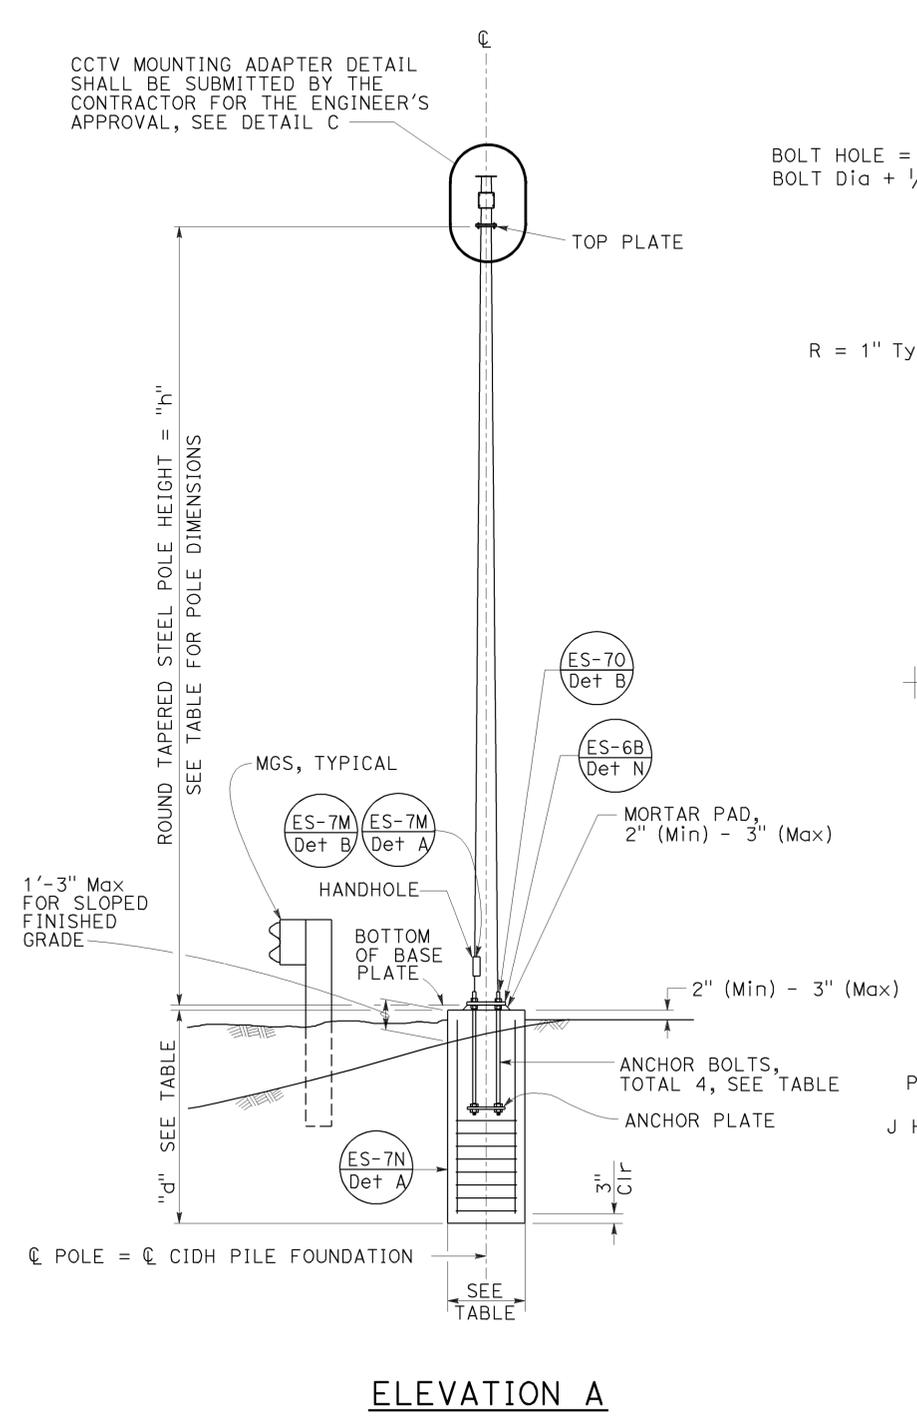


ELEVATION A

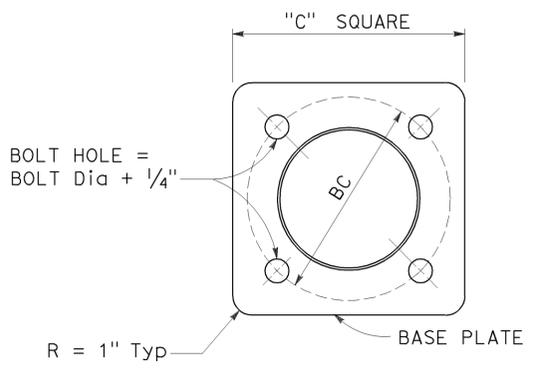


BASE PLATE  
DETAIL A

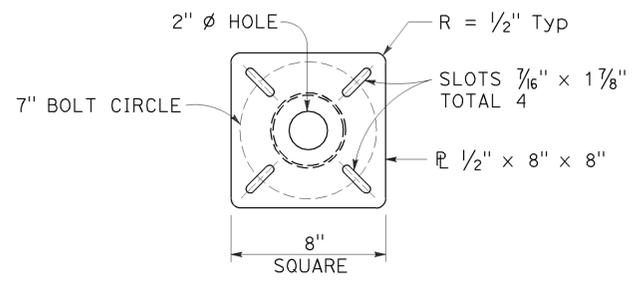


TOP PLATE  
DETAIL B

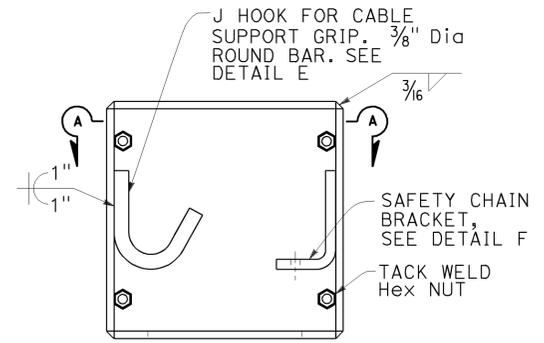


BOX ENCLOSURE  
DETAIL D

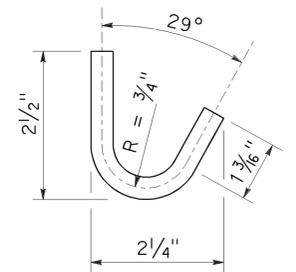


J HOOK  
DETAIL E

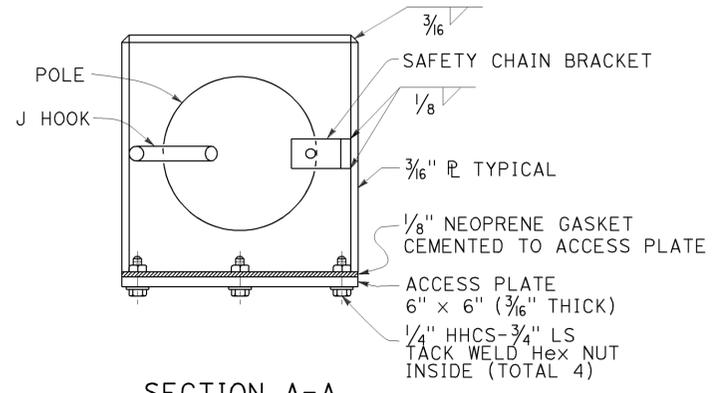

SECTION A-A

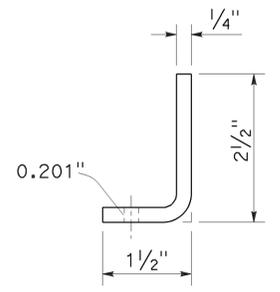

SAFETY CHAIN BRACKET  
DETAIL F

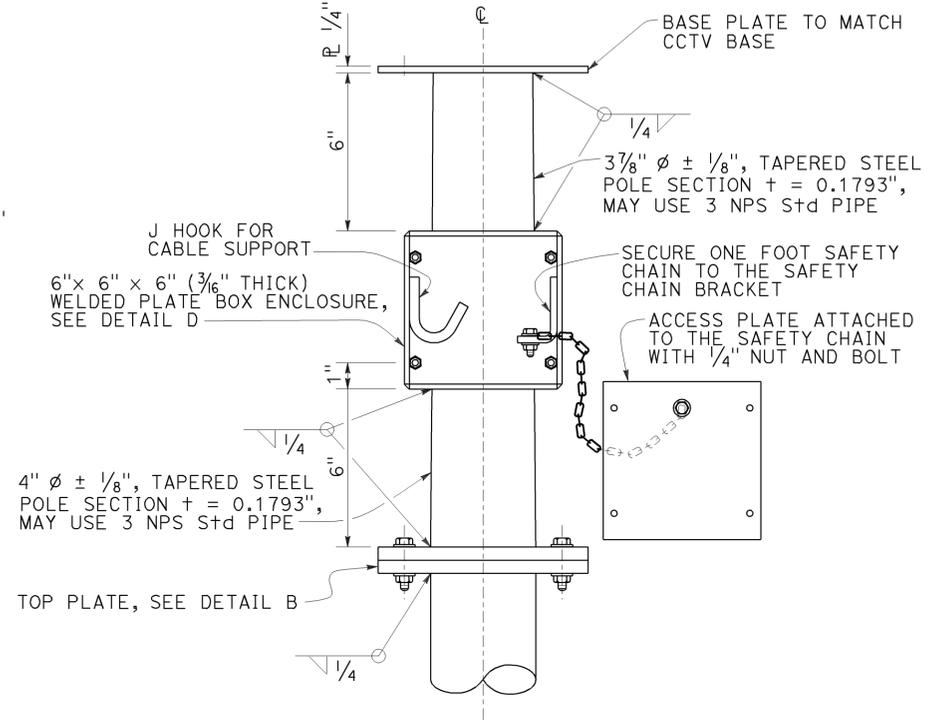

CLOSED CIRCUIT TELEVISION MOUNTING ADAPTER  
DETAIL C

NOTES:

- The Contractor shall verify controlling field dimensions before ordering or fabricating any material.
- During pole installation, the post shall be raked as necessary with the use of leveling nuts to provide a plumb pole axis.
- Wind Loadings (3-second gust): 100 mph
- Unit Stresses (Structural Steel):
  - fy = 55,000 psi (tapered steel tube and anchor bolts)
  - fy = 50,000 psi (unless otherwise noted)
- Unit Stresses (Reinforced Concrete):
  - f'c = 3,625 psi
  - fy = 60,000 psi

STATE OF CALIFORNIA  
DEPARTMENT OF TRANSPORTATION

**ELECTRICAL SYSTEMS  
(CLOSED CIRCUIT TELEVISION,  
25' TO 45' POLE)**

NO SCALE

RSP ES-16B DATED NOVEMBER 15, 2013 SUPERSEDES STANDARD PLAN ES-16B DATED MAY 20, 2011 - PAGE 501 OF THE STANDARD PLANS BOOK DATED 2010.

**REVISED STANDARD PLAN RSP ES-16B**


2010 REVISED STANDARD PLAN RSP ES-16B

Dist	COUNTY	ROUTE	POST MILES TOTAL PROJECT	SHEET No.	TOTAL SHEETS
07	LA	110	8.6/14.0	112	121

*Gregory A. Balzer*  
LICENSED LANDSCAPE ARCHITECT

July 19, 2013  
PLANS APPROVAL DATE

THE STATE OF CALIFORNIA OR ITS OFFICERS OR AGENTS SHALL NOT BE RESPONSIBLE FOR THE ACCURACY OR COMPLETENESS OF SCANNED COPIES OF THIS PLAN SHEET.

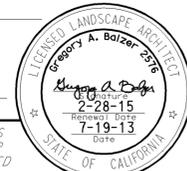

TO ACCOMPANY PLANS DATED 5-26-15

**A**

AB AGGREGATE BASE  
 ABS ACRYLONITRILE-BUTADIENE-STYRENE  
 AC ASPHALT CONCRETE  
 ACC ARMOR-CLAD CONDUCTORS  
 Adj ADJACENT/ADJUSTABLE  
 AIC AUXILIARY IRRIGATION CONTROLLER  
 Alt ALTERNATIVE  
 AMEND AMENDMENT  
 ARV AIR RELEASE VALVE  
 AUTO AUTOMATIC  
 AUX AUXILIARY  
 AVB ATMOSPHERIC VACUUM BREAKER

**B**

B&B BALLED AND BURLAPPED  
 B/B BRASS/BRONZE  
 B/B/PL BRASS/BRONZE/PLASTIC  
 B/PL BRASS/PLASTIC  
 BFM BONDED FIBER MATRIX  
 Bit Ctd BITUMINOUS COATED  
 BP BOOSTER PUMP  
 BPA BACKFLOW PREVENTER ASSEMBLY  
 BPE BACKFLOW PREVENTER ENCLOSURE  
 BV BALL VALVE

**C**

C CONDUIT  
 CAP CORRUGATED ALUMINUM PIPE  
 CARV COMBINATION AIR RELEASE VALVE  
 CB COUPLING BAND  
 CCA CAM COUPLER ASSEMBLY  
 CEC CONTROLLER ENCLOSURE CABINET  
 CHDPE CORRUGATED HIGH DENSITY POLYETHYLENE  
 CL CHAIN LINK  
 CNC CONTROL AND NEUTRAL CONDUCTORS  
 Conc CONCRETE  
 CP COPPER PIPE  
 CS COMPOST SOCK  
 CSP CORRUGATED STEEL PIPE  
 CST CENTER STRIP  
 CV CHECK VALVE

**D**

Dia DIAMETER  
 DIP DUCTILE IRON PIPE  
 DIT DRIP IRRIGATION TUBING  
 DG DECOMPOSED GRANITE  
 DN DIAMETER NOMINAL  
 DVA DRIP VALVE ASSEMBLY

**E**

EC EROSION CONTROL  
 ECTC EROSION CONTROL TECHNOLOGY COUNCIL  
 ElecT ELECTRIC/ELECTRICAL  
 Elev ELEVATION  
 ELL ELBOW  
 ENCL ENCLOSURE  
 EP EDGE OF PAVEMENT  
 ES EDGE OF SHOULDER  
 EST END STRIP  
 ESTB ESTABLISHMENT  
 ETW EDGE OF TRAVELED WAY

**F**

F FULL CIRCLE  
 F/P FULL/PART CIRCLE  
 FCV FLOW CONTROL VALVE  
 FERT FERTILIZER  
 FG FINISHED GRADE  
 FH FLEXIBLE HOSE  
 FIPT FEMALE IRON PIPE THREAD  
 FIS FERTILIZER INJECTOR SYSTEM  
 FL FLOW LINE  
 FR FIBER ROLL  
 FS FLOW SENSOR  
 FSC FLOW SENSOR CABLE  
 FV FLUSH VALVE

**G**

Galv GALVANIZED  
 GARV GARDEN VALVE  
 GARVA GARDEN VALVE ASSEMBLY  
 GM GRAVEL MULCH  
 GPH GALLONS PER HOUR  
 GPM GALLONS PER MINUTE  
 GSP GALVANIZED STEEL PIPE  
 GV GATE VALVE

**H**

H HALF CIRCLE  
 HDPE HIGH DENSITY POLYETHYLENE  
 HP HORSEPOWER/HINGE POINT  
 HPL HIGH PRESSURE LINE  
 Hwy HIGHWAY

**I**

IC IRRIGATION CONTROLLER  
 ICC IRRIGATION CONTROLLER(S)  
 IN CONTROLLER ENCLOSURE CABINET  
 ID INSIDE DIAMETER  
 IFS IRRIGATION FILTRATION SYSTEM  
 IPS IRON PIPE SIZE  
 IPT IRON PIPE THREAD  
 Irr IRRIGATION

**L**

L LENGTH

**M**

Max MAXIMUM  
 MBGR METAL BEAM GUARD RAILING  
 MCV MANUAL CONTROL VALVE  
 MIC MASTER IRRIGATION CONTROLLER  
 Min MINIMUM  
 MIPT MALE IRON PIPE THREAD  
 Misc MISCELLANEOUS  
 MtI MATERIAL  
 MVP MAINTENANCE VEHICLE PULLOUT

**N**

NCN NO COMMON NAME  
 NL NOZZLE LINE  
 No. NUMBER  
 NPT NATIONAL PIPE THREAD

**O**

O/C ON CENTER  
 OD OUTSIDE DIAMETER  
 OL OVERLAP

**P**

P PART CIRCLE  
 PB PULL BOX  
 PCC PORTLAND CEMENT CONCRETE  
 PE POLYETHYLENE  
 Pkt+ PACKET  
 PL PLASTIC  
 PLS PURE LIVE SEED  
 PLT PLANT/PLANTING  
 PLT ESTB PLANT ESTABLISHMENT  
 PM POST MILE  
 PR PRESSURE RATED  
 PRLV PRESSURE RELIEF VALVE  
 PRV PRESSURE REGULATING VALVE  
 PVC POLYVINYL CHLORIDE  
 Pvm+ PAVEMENT

**Q**

Q QUARTER CIRCLE  
 QCV QUICK COUPLING VALVE

**NOTE:**  
 For additional abbreviations,  
 see Standard Plans A10A and A10B.

**R**

R RADIUS  
 RCP REINFORCED CONCRETE PIPE  
 RCV REMOTE CONTROL VALVE  
 RCVM REMOTE CONTROL VALVE (MASTER)  
 RCVMF REMOTE CONTROL VALVE (MASTER) W/FLOW SENSOR  
 RCVP REMOTE CONTROL VALVE W/PRESSURE REGULATOR  
 RCW RECYCLED WATER  
 RECP ROLLED EROSION CONTROL PRODUCT  
 REQ REQUIRED  
 RICS REMOTE IRRIGATION CONTROL SYSTEM  
 R/W RIGHT OF WAY

**S**

S SLIP  
 SCH SCHEDULE  
 SF STATE-FURNISHED  
 Shld SHOULDER  
 Sq SQUARE  
 SST SIDE STRIP  
 Sta STATION  
 Std STANDARD  
 SW SIDEWALK/SOUND WALL

**T**

T THIRD CIRCLE/THREAD  
 TLS TRUCK LOADING STANDPIPE  
 TQ THREE QUARTER CIRCLE  
 TRM TURF REINFORCEMENT MAT  
 TT TWO-THIRDS CIRCLE  
 TWSA TREE WELL SPRINKLER ASSEMBLY  
 Typ TYPICAL

**U**

UG UNDERGROUND

**W**

W WIDTH  
 W/ WITH  
 WM WATER METER  
 WS WYE STRAINER  
 WSA WYE STRAINER ASSEMBLY  
 WSP WELDED STEEL PIPE  
 WWM WELDED WIRE MESH

STATE OF CALIFORNIA  
 DEPARTMENT OF TRANSPORTATION  
**LANDSCAPE AND  
 EROSION CONTROL ABBREVIATIONS**  
 NO SCALE

RSP H1 DATED JULY 19, 2013 SUPERSEDES STANDARD PLAN H1  
 DATED MAY 20, 2011 - PAGE 218 OF THE STANDARD PLANS BOOK DATED 2010.

**REVISED STANDARD PLAN RSP H1**

2010 REVISED STANDARD PLAN RSP H1

Dist	COUNTY	ROUTE	POST MILES TOTAL PROJECT	SHEET No.	TOTAL SHEETS
07	LA	110	8.6/14.0	113	121

*Gregory A. Balzer*  
LICENSED LANDSCAPE ARCHITECT

November 15, 2013  
PLANS APPROVAL DATE


THE STATE OF CALIFORNIA OR ITS OFFICERS OR AGENTS SHALL NOT BE RESPONSIBLE FOR THE ACCURACY OR COMPLETENESS OF SCANNED COPIES OF THIS PLAN SHEET.

TO ACCOMPANY PLANS DATED 5-26-15

2010 REVISED STANDARD PLAN RSP H2

EXISTING	NEW	ITEM DESCRIPTION
		WATER METER (WM)
		BACKFLOW PREVENTER ASSEMBLY (BPA)
		BACKFLOW PREVENTER ENCLOSURE (BPE)
		BOOSTER PUMP (BP)
		TRUCK LOADING STANDPIPE (TLS)
		FLOW SENSOR (FS)
		MASTER IRRIGATION CONTROLLER (MIC)
		AUXILIARY IRRIGATION CONTROLLER (AIC)
		IRRIGATION CONTROLLER (IC)
		IRRIGATION CONTROLLER (IC) (BATTERY)
		IRRIGATION CONTROLLER (IC) (SOLAR)
		IRRIGATION CONTROLLER (IC) (TWO WIRE)
		IRRIGATION CONTROLLER(S) IN CONTROLLER ENCLOSURE CABINET (ICC)
		ARMOR-CLAD CONDUCTORS (ACC)
		CONTROL AND NEUTRAL CONDUCTORS (CNC)
		IRRIGATION CONDUIT
		EXTEND IRRIGATION CONDUIT
		DUCTILE IRON PIPE (SUPPLY LINE) (MAIN) (DIP)
		GALVANIZED STEEL PIPE (SUPPLY LINE) (MAIN) (GSP)
		GALVANIZED STEEL PIPE (SUPPLY LINE) (LATERAL) (GSP)
		PLASTIC PIPE (SUPPLY LINE) (MAIN)
		PLASTIC PIPE (SUPPLY LINE) (LATERAL)
		COPPER PIPE (SUPPLY LINE)
		DRIP IRRIGATION TUBING
		REMOTE CONTROL VALVE (RCV)
		REMOTE CONTROL VALVE (MASTER) (RCVM)
		REMOTE CONTROL VALVE (MASTER) W/FLOW METER (RCVMF)
		REMOTE CONTROL VALVE W/PRESSURE REGULATOR (RCVP)
		EXISTING MANUAL CONTROL VALVE (MCV)
		DRIP VALVE ASSEMBLY (DVA)
		WYE STRAINER ASSEMBLY (WSA)

EXISTING	NEW	ITEM DESCRIPTION
		GATE VALVE (GV)
		BALL VALVE (BV)
		QUICK COUPLING VALVE (QCV)
		CAM COUPLER ASSEMBLY (CCA)
		GARDEN VALVE ASSEMBLY (GARVA)
		PRESSURE REGULATING VALVE (PRV)
		PRESSURE RELIEF VALVE (PRLV)
		FLOW CONTROL VALVE (FCV)
		COMBINATION AIR RELEASE VALVE (CARV)
		CHECK VALVE (CV)
		FLUSH VALVE (FV)
		EXISTING NOZZLE LINE W/TURNING UNION
		EXISTING IRRIGATION SYSTEM
		EXISTING IRRIGATION SYSTEM TO BE REMOVED
		CHAIN LINK GATE
		QUICK COUPLING VALVE W/SPRINKLER PROTECTOR
		SPRINKLER W/SPRINKLER PROTECTOR
		CONNECT TO EXISTING SYSTEM
		CAP
		CAP EXISTING
		FIBER ROLL
		COMPOST SOCK

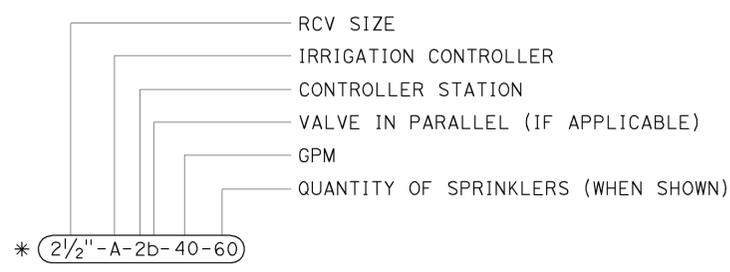

\* 2 1/2" - A - 2b - 40 - 60

**VALVE CODE**

\* VALVE CODES FOR EXISTING VALVES ARE SHOWN IN A DASHED ENCLOSURE.

STATE OF CALIFORNIA  
DEPARTMENT OF TRANSPORTATION  
**LANDSCAPE AND EROSION  
CONTROL SYMBOLS**  
NO SCALE


RSP H2 DATED NOVEMBER 15, 2013 SUPERSEDES RSP H2 DATED JULY 19, 2013 AND STANDARD PLAN H2 DATED MAY 20, 2011 - PAGE 219 OF THE STANDARD PLANS BOOK DATED 2010.

**REVISED STANDARD PLAN RSP H2**

Dist	COUNTY	ROUTE	POST MILES TOTAL PROJECT	SHEET No.	TOTAL SHEETS
07	LA	110	8.6/14.0	114	121

Stanley P. Johnson  
 REGISTERED CIVIL ENGINEER  
 July 19, 2013  
 PLANS APPROVAL DATE  
 THE STATE OF CALIFORNIA OR ITS OFFICERS OR AGENTS SHALL NOT BE RESPONSIBLE FOR THE ACCURACY OR COMPLETENESS OF SCANNED COPIES OF THIS PLAN SHEET.


2010 REVISED STANDARD PLAN RSP S140

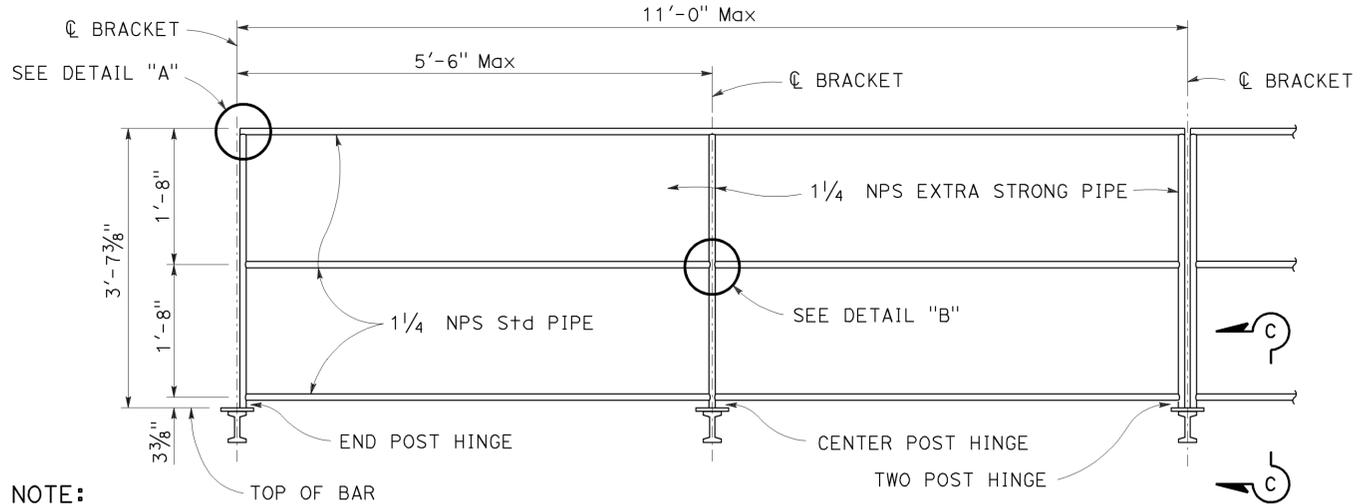


**SAFETY RAILING ELEVATION**

**NOTE:**  
Chain assembly behind (see detail this page)


**NOTE:**  
See Standard Plans S101 and S105 and S109 for walkway bracket spacing.

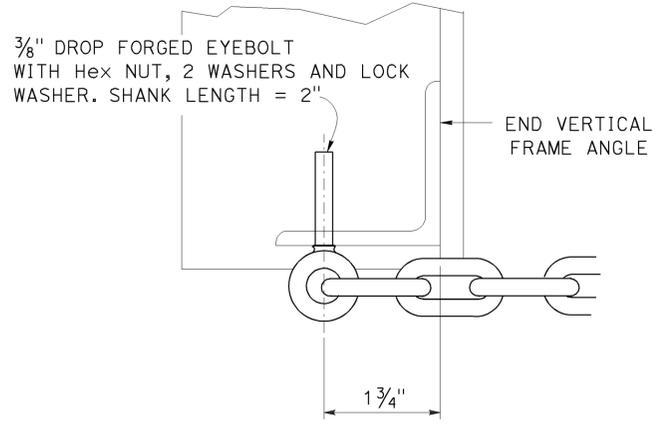


**SECTION D-D**

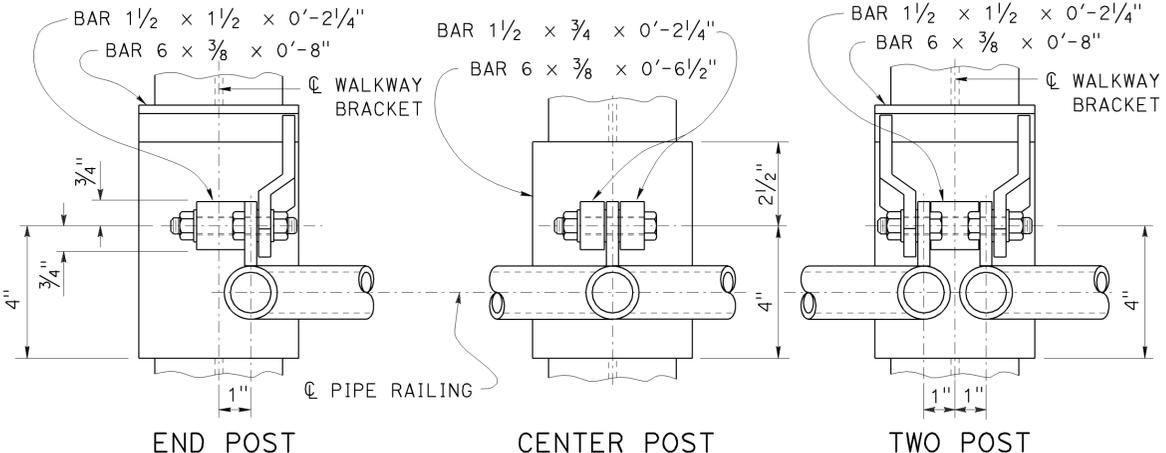


**WELDED HINGE - PLAN**

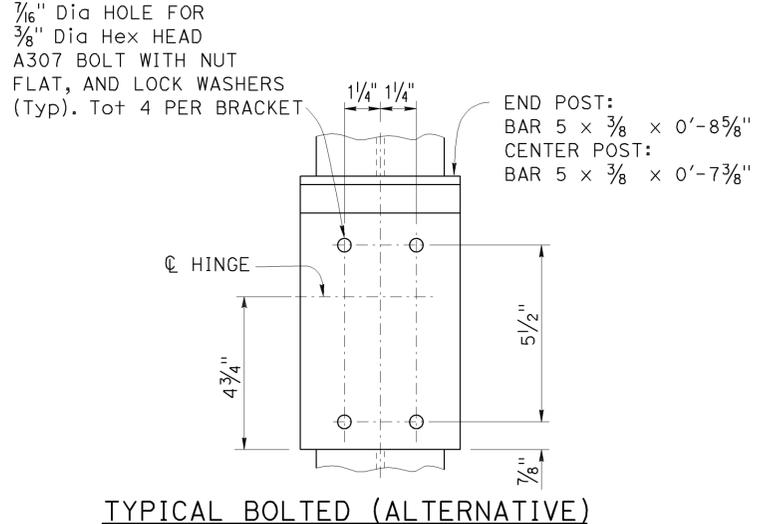


**TYPICAL BOLTED (ALTERNATIVE) HINGED CONNECTION**

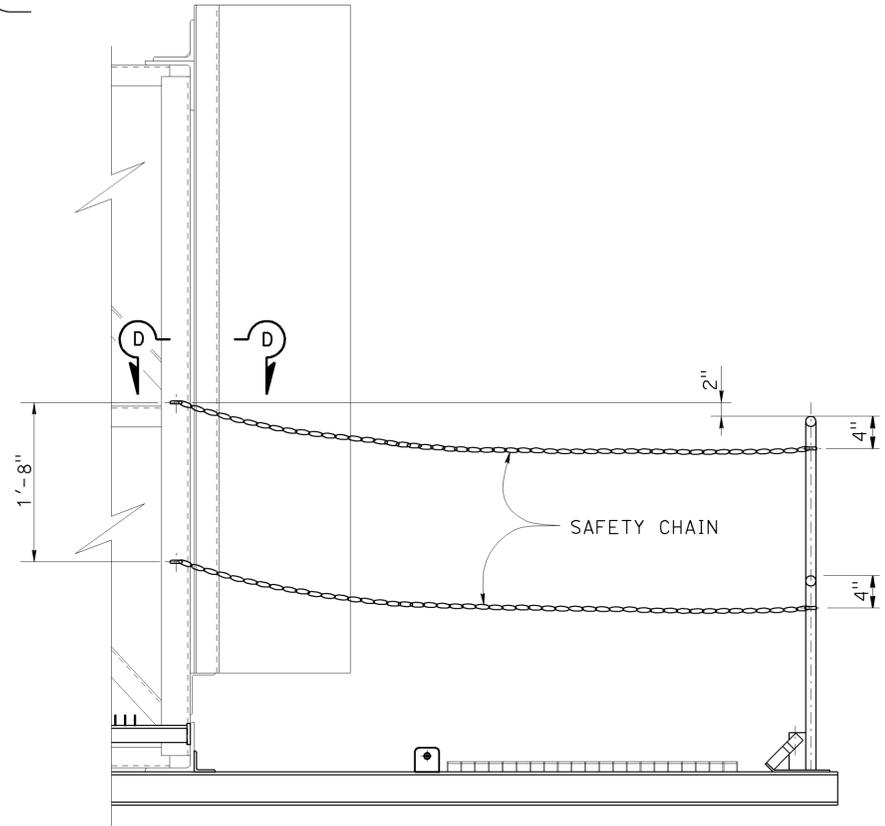


**CHAIN ASSEMBLY**

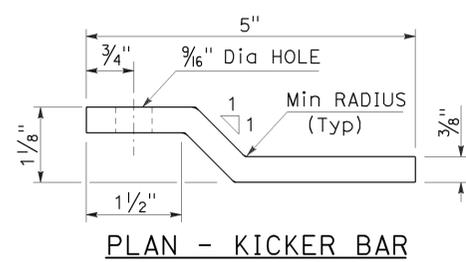

**PLAN - KICKER BAR**

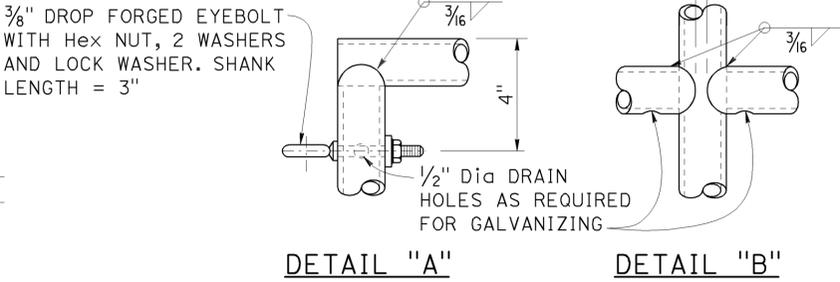

**NOTE:**  
Alternative venting methods may be used if approved by the Engineer.

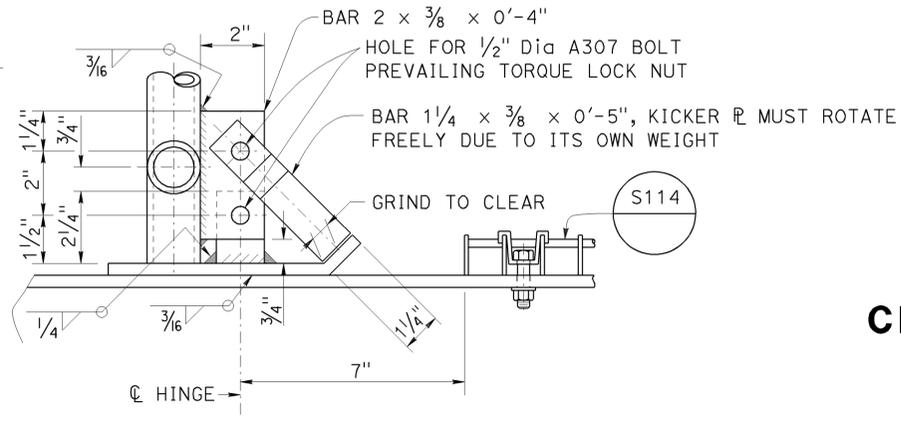

**SECTION C-C ELEVATION VIEW**


STATE OF CALIFORNIA  
 DEPARTMENT OF TRANSPORTATION  
**OVERHEAD SIGN-TRUSS  
 SINGLE POST TYPE  
 WALKWAY SAFETY  
 RAILING DETAILS  
 CHANGEABLE MESSAGE SIGNS  
 MODEL 500 AND 510**  
 NO SCALE

RSP S140 DATED JULY 19, 2013 SUPERSEDES STANDARD PLAN S140 DATED MAY 20, 2011 - PAGE 422 OF THE STANDARD PLANS BOOK DATED 2010.




**REVISED STANDARD PLAN RSP S140**

Dist	COUNTY	ROUTE	POST MILES TOTAL PROJECT	SHEET No.	TOTAL SHEETS
07	LA	110	8.6/14.0	115	121

Stanley P. Johnson  
 REGISTERED CIVIL ENGINEER  
 July 19, 2013  
 PLANS APPROVAL DATE  
 THE STATE OF CALIFORNIA OR ITS OFFICERS OR AGENTS SHALL NOT BE RESPONSIBLE FOR THE ACCURACY OR COMPLETENESS OF SCANNED COPIES OF THIS PLAN SHEET.

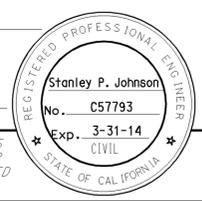


TO ACCOMPANY PLANS DATED 5-26-15

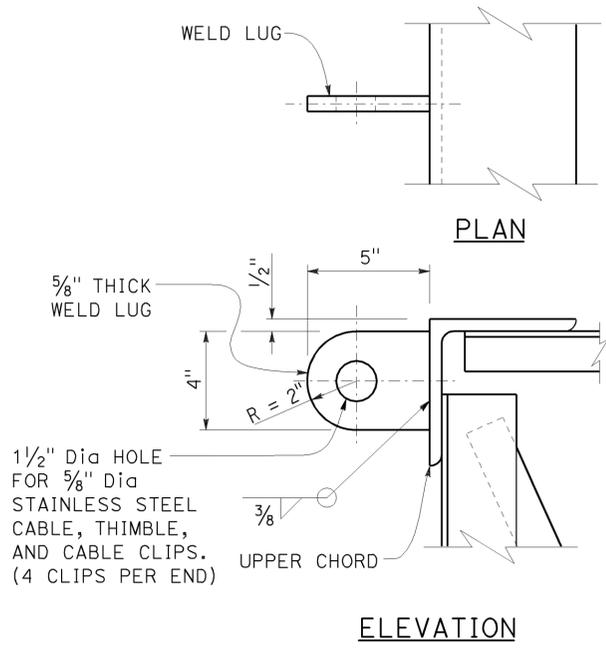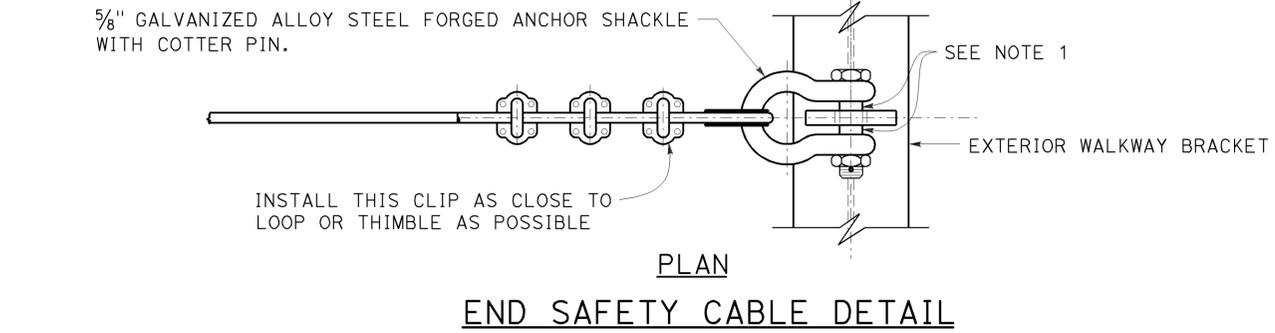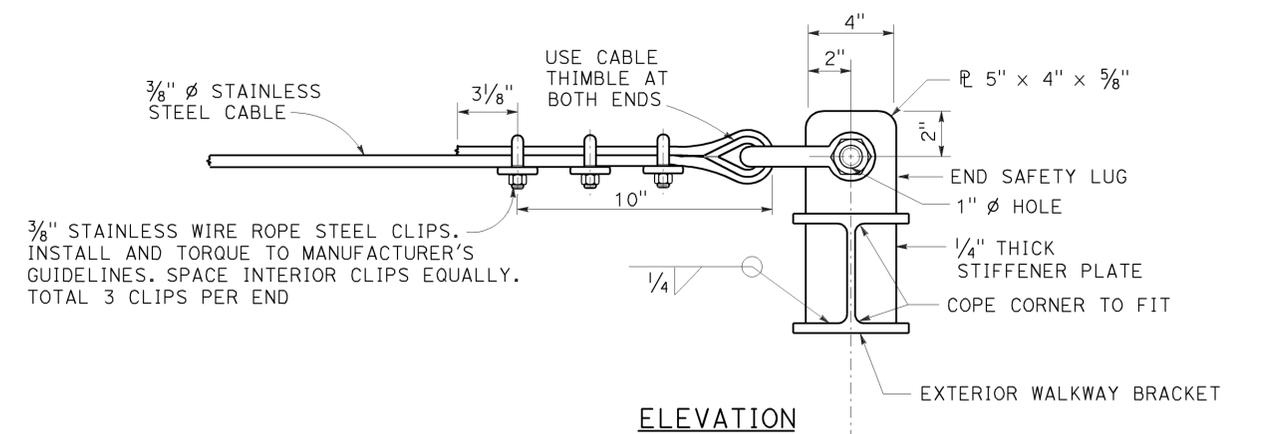

**NOTE:** Backside weld lug shall be installed only for projects requiring backside walkways.

**NOTES:**

1. Place an equal amount of washers on each side to align cable with end lug without restricting shackle bolt rotation or contacting cable.
2. For walkway grating details, see Standard Plan S114.

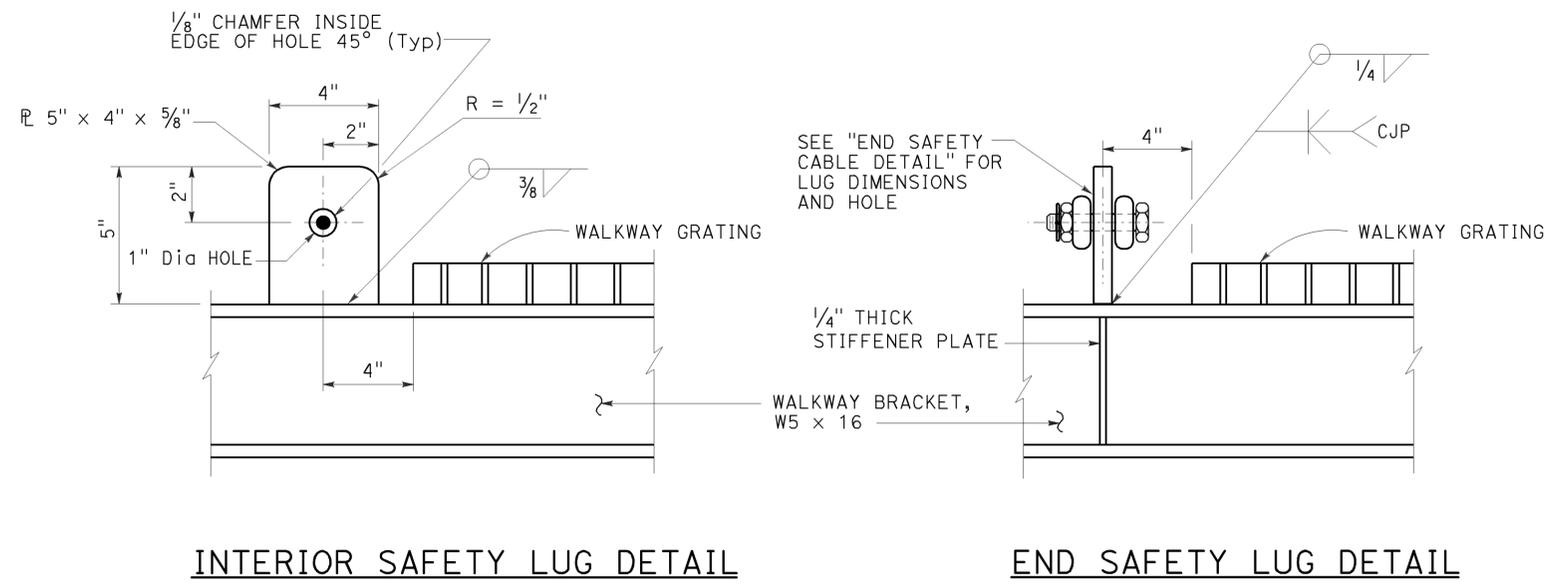

STATE OF CALIFORNIA  
 DEPARTMENT OF TRANSPORTATION  
**OVERHEAD SIGN-TRUSS  
 SINGLE POST TYPE  
 SAFETY CABLE  
 ANCHORAGE DETAILS  
 CHANGEABLE MESSAGE SIGNS  
 MODEL 500 AND 510**

NO SCALE

RSP S141 DATED JULY 19, 2013 SUPERSEDES STANDARD PLAN S141 DATED MAY 20, 2011 - PAGE 423 OF THE STANDARD PLANS BOOK DATED 2010.

**REVISED STANDARD PLAN RSP S141**

2010 REVISED STANDARD PLAN RSP S141

TO ACCOMPANY PLANS DATED 5-26-15

TABLE 1

TAPER LENGTH CRITERIA AND CHANNELIZING DEVICE SPACING							
SPEED (S)	MINIMUM TAPER LENGTH * FOR WIDTH OF OFFSET 12 FEET (W)				MAXIMUM CHANNELIZING DEVICE SPACING		
	TANGENT 2L	MERGING L	SHIFTING L/2	SHOULDER L/3	X	Y	Z **
					TAPER	TANGENT	CONFLICT
mph	ft	ft	ft	ft	ft	ft	ft
20	160	80	40	27	20	40	10
25	250	125	63	42	25	50	12
30	360	180	90	60	30	60	15
35	490	245	123	82	35	70	17
40	640	320	160	107	40	80	20
45	1080	540	270	180	45	90	22
50	1200	600	300	200	50	100	25
55	1320	660	330	220	55	110	27
60	1440	720	360	240	60	120	30
65	1560	780	390	260	65	130	32
70	1680	840	420	280	70	140	35

\* - For other offsets, use the following merging taper length formula for L:  
 For speed of 40 mph or less,  $L = WS^2/60$   
 For speed of 45 mph or more,  $L = WS$

Where: L = Taper length in feet  
 W = Width of offset in feet  
 S = Posted speed limit, off-peak 85th-percentile speed prior to work starting, or the anticipated operating speed in mph

\*\* - Use for taper and tangent sections where there are no pavement markings or where there is a conflict between existing pavement markings and channelizers (CA).

TABLE 2

LONGITUDINAL BUFFER SPACE AND FLAGGER STATION SPACING				
SPEED *	Min D **	DOWNGRADE Min D ***		
		-3%	-6%	-9%
		ft	ft	ft
20	115	116	120	126
25	155	158	165	173
30	200	205	215	227
35	250	257	271	287
40	305	315	333	354
45	360	378	400	427
50	425	446	474	507
55	495	520	553	593
60	570	598	638	686
65	645	682	728	785
70	730	771	825	891

\* - Speed is posted speed limit, off-peak 85th-percentile speed prior to work starting, or the anticipated operating speed in mph  
 \*\* - Longitudinal buffer space or flagger station spacing  
 \*\*\* - Use on sustained downgrade steeper than -3 percent and longer than 1 mile.

TABLE 3

ADVANCE WARNING SIGN SPACING			
ROAD TYPE	DISTANCE BETWEEN SIGNS *		
	A	B	C
	ft	ft	ft
URBAN - 25 mph OR LESS	100	100	100
URBAN - MORE THAN 25 mph TO 40 mph	250	250	250
URBAN - MORE THAN 40 mph	350	350	350
RURAL	500	500	500
EXPRESSWAY / FREEWAY	1000	1500	2640

\* - The distances are approximate, are intended for guidance purposes only, and should be applied with engineering judgment. These distances should be adjusted by the Engineer for field conditions, if necessary, by increasing or decreasing the recommended distances.

STATE OF CALIFORNIA  
 DEPARTMENT OF TRANSPORTATION  
**TRAFFIC CONTROL SYSTEM TABLES  
 FOR LANE AND RAMP CLOSURES**

NO SCALE

RSP T9 DATED JULY 19, 2013 SUPERSEDES RSP T9 DATED APRIL 19, 2013 THAT SUPPLEMENTS THE STANDARD PLANS BOOK DATED 2010.


2010 REVISED STANDARD PLAN RSP T9

DIST	COUNTY	ROUTE	POST MILES TOTAL PROJECT	SHEET No.	TOTAL SHEETS
07	LA	110	8.6/14.0	117	121

REGISTERED CIVIL ENGINEER  
 April 19, 2013  
 PLANS APPROVAL DATE

REGISTERED PROFESSIONAL ENGINEER  
 Gurinderpal Bhullar  
 No. C48815  
 Exp. 9-30-14  
 CIVIL  
 STATE OF CALIFORNIA

THE STATE OF CALIFORNIA OR ITS OFFICERS OR AGENTS SHALL NOT BE RESPONSIBLE FOR THE ACCURACY OR COMPLETENESS OF SCANNED COPIES OF THIS PLAN SHEET.

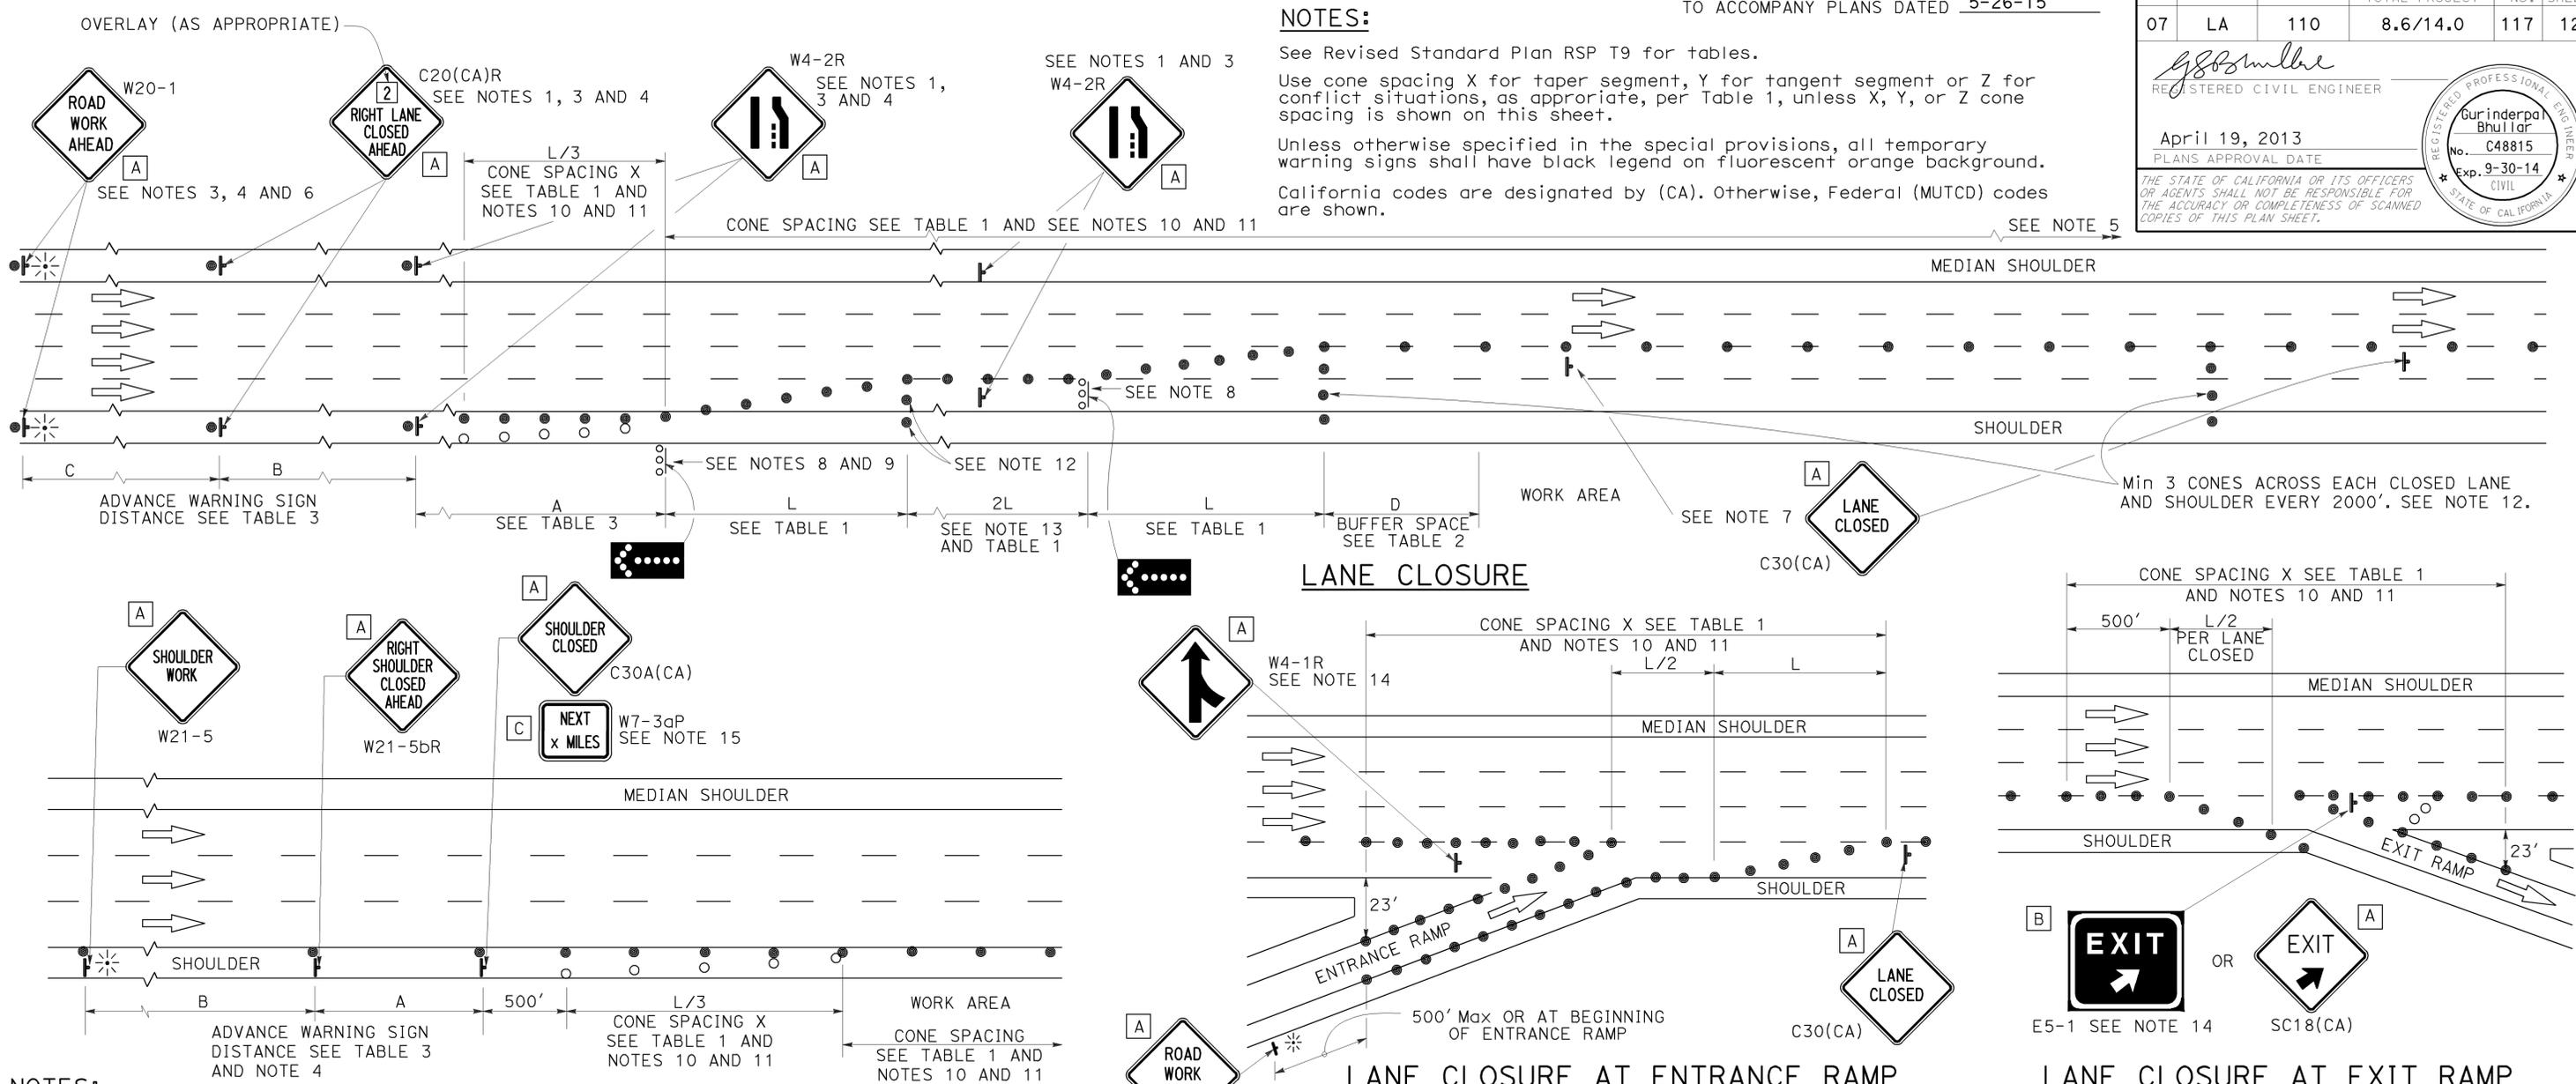

- NOTES:**
1. Median lane closures shall conform to the details as shown except that C20(CA)L and W4-2L signs shall be used.
  2. At least one person shall be assigned to provide full time maintenance of traffic control devices for lane closures.
  3. Duplicate sign installations are not required:
    - a) On opposite shoulder if at least one-half of the available lanes remain open to traffic.
    - b) In the median if the width of the median shoulder is less than 8' and the outside lanes are to be closed.
  4. Each advance warning sign on each side of the roadway shall be equipped with at least two flags for daytime closure. Each flag shall be at least 16" x 16" in size and shall be orange or fluorescent red-orange in color. Flashing beacons shall be placed at the locations indicated for lane closure during hours of darkness.
  5. A G20-2 "END ROAD WORK" sign, with minimum size of 48" x 24" as appropriate, shall be placed at the end of the lane closure unless the end of work area is obvious or ends within a larger project's limits.

- SHOULDER CLOSURE**
6. If the W20-1 sign would follow within 2000' of a stationary W20-1 or G20-1 "ROAD WORK NEXT \_\_\_\_\_ MILES", use a C20(CA)L and W4-2L signs shall be used.
  7. Place a C30(CA) sign every 2000' throughout length of lane closure.
  8. One flashing arrow sign for each lane closed. The flashing arrow signs shall be Type I.
  9. A minimum 1500' of sight distance shall be provided where possible for vehicles approaching the first flashing arrow sign. Lane closures shall not begin at top of crest vertical curve or on a horizontal curve.
  10. All cones used for lane closures during the hours of darkness shall be fitted with retroreflective bands (or sleeves) as specified in the specifications.
  11. Portable delineators, placed at one-half the spacing indicated for traffic cones may be used instead of cones for daytime closures only.

- LANE CLOSURE AT ENTRANCE RAMP**
- LANE CLOSURE AT EXIT RAMP**
12. Unless otherwise specified in the special provisions, a minimum of 3 cones shall be placed transversely across each closed lane and shoulder at each location where a taper across a traffic lane ends and every 2000' as shown on the "Lane Closure" detail. Two Type II barricades may be used instead of the 3 cones. The transverse alignment of the cones or barricades on the closed shoulder may be shifted from the transverse alignment to provide access to the work.
  13. Unless otherwise specified in the special provisions, the 2L tangent shown along lane lines shall be used between the L tapers required for each closed traffic lane.
  14. Unless otherwise specified in the special provisions, the E5-1 or SC18(CA) and W4-1 signs shall be used as shown.
  15. A W7-3aP "NEXT \_\_\_\_\_ MILES" plaque must be used if the shoulder closure extends beyond the distance that can be perceived by road users.

**LEGEND**

- TRAFFIC CONE
- TRAFFIC CONE (OPTIONAL TAPER)
- † TEMPORARY TRAFFIC CONTROL SIGN
- FLASHING ARROW SIGN (FAS)
- FAS SUPPORT OR TRAILER
- ⚡ PORTABLE FLASHING BEACON

**SIGN PANEL SIZE (Min)**

A	48" x 48"
B	72" x 60"
C	36" x 30"

STATE OF CALIFORNIA  
 DEPARTMENT OF TRANSPORTATION

**TRAFFIC CONTROL SYSTEM  
 FOR LANE CLOSURE ON  
 FREEWAYS AND EXPRESSWAYS**

NO SCALE

RSP T10 DATED APRIL 19, 2013 SUPERSEDES STANDARD PLAN T10 DATED MAY 20, 2011 - PAGE 237 OF THE STANDARD PLANS BOOK DATED 2010.

**REVISED STANDARD PLAN RSP T10**

2010 REVISED STANDARD PLAN RSP T10

**NOTES:**

See Revised Standard Plan RSP T9 for tables.


Use cone spacing X for taper segment, Y for tangent segment or Z for conflict situations, as appropriate, per Table 1, unless X, Y, or Z cone spacing is shown on this sheet.

Unless otherwise specified in the special provisions, all temporary warning signs shall have black legend on fluorescent orange background.

California codes are designated by (CA). Otherwise, Federal (MUTCD) codes are shown.


**TYPICAL LANE CLOSURE WITH REVERSIBLE CONTROL**

TO ACCOMPANY PLANS DATED 5-26-15

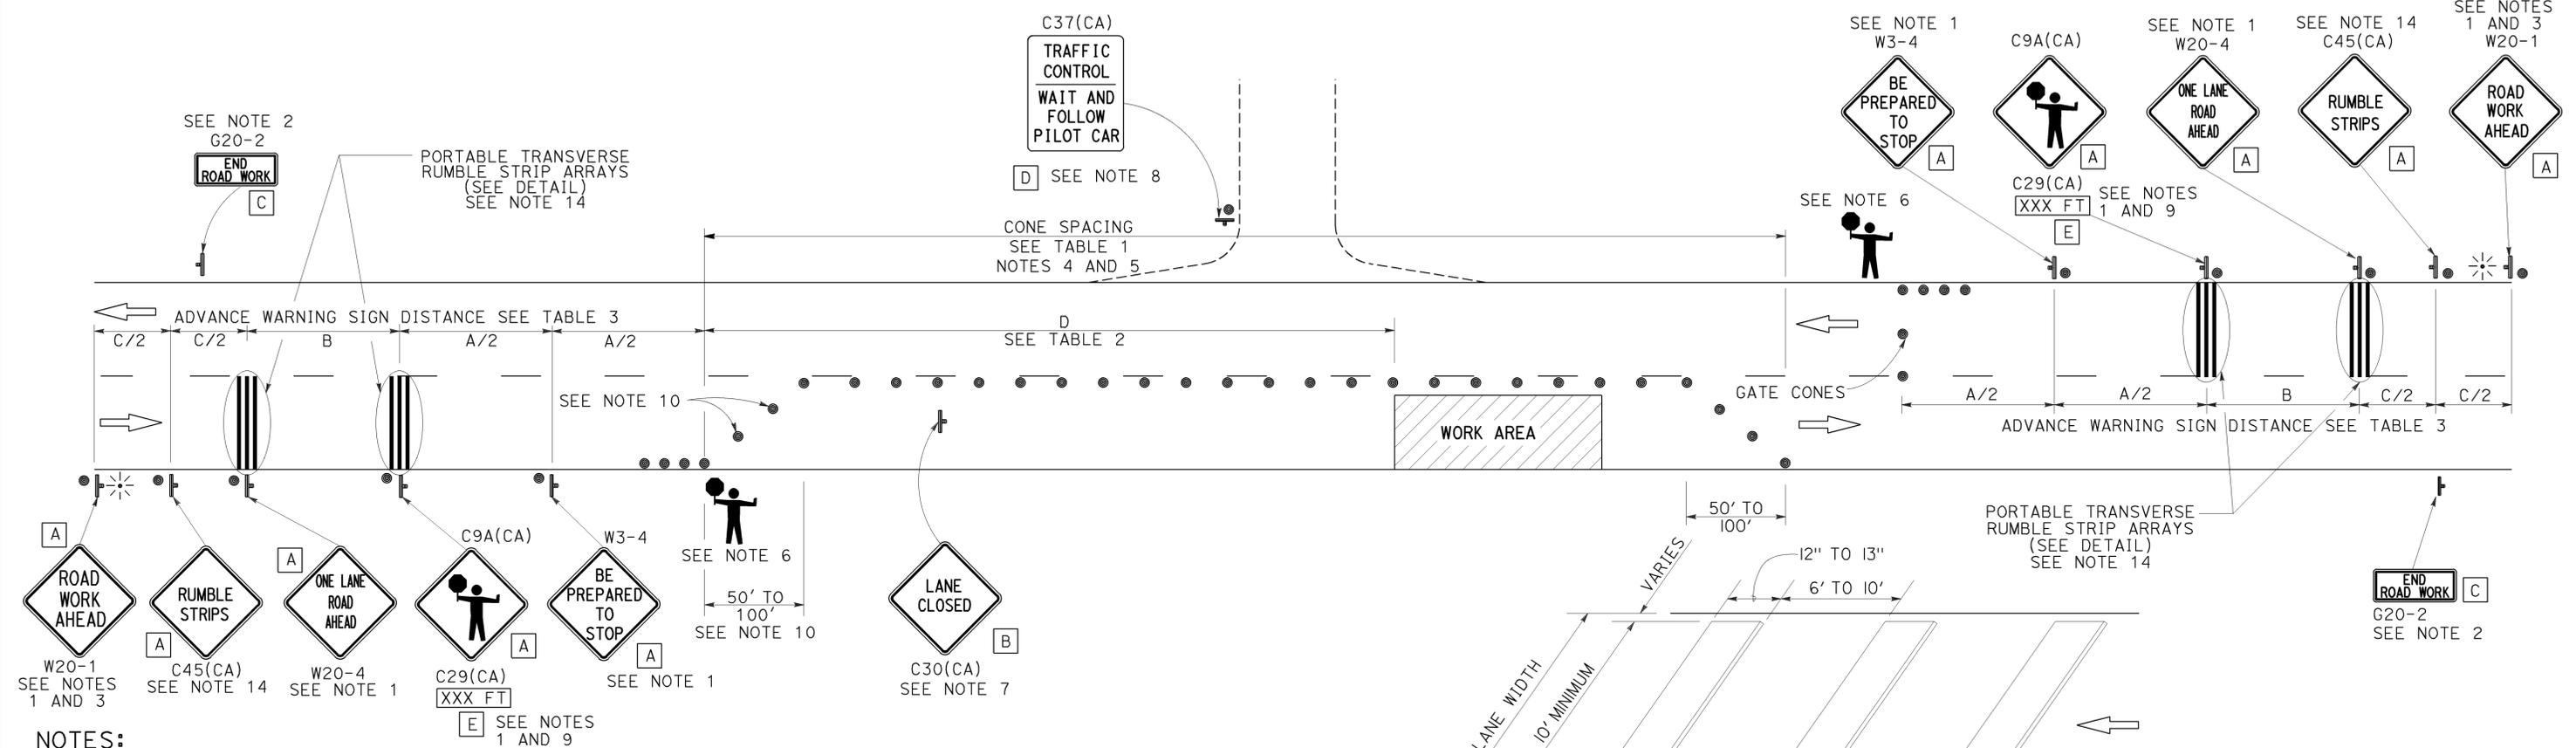

- NOTES:**
- Each advance warning sign in each direction of travel shall be equipped with at least two flags for daytime closure. Each flag shall be at least 16" x 16" in size and shall be orange or fluorescent red-orange in color. Flashing beacons shall be placed at the locations indicated for lane closure during hours of darkness.
  - A G20-2 "END ROAD WORK" sign, as appropriate, shall be placed at the end of the lane control unless the end of work area is obvious, or ends within a larger project's limits.
  - If the W20-1 sign would follow within 2000' of a stationary W20-1 or G20-1 "ROAD WORK NEXT \_\_\_\_\_ MILES", use a W20-4 sign for the first advance warning sign.
  - All cones used for lane closures during the hours of darkness shall be fitted with retroreflective bands (or sleeves) as specified in the specifications.
  - Portable delineators, placed at one-half the spacing indicated for traffic cones, may be used instead of cones for daytime closures only.
  - Additional advance flaggers may be required. Flagger should stand in a conspicuous place, be visible to approaching traffic as well as approaching vehicles after the first vehicle has stopped. During the hours of darkness, the flagging-station and flagger shall be illuminated and clearly visible to approaching traffic. The illumination footprint of the lighting on the ground shall be at least 20' in diameter. Place a minimum of four cones at 50' intervals in advance of flagger station as shown.

- Place C30(CA) "LANE CLOSED" sign at 500' to 1000' intervals throughout extended work areas. They are optional if the work area is visible from the flagger station.
- When a pilot car is used, place a C37(CA) "TRAFFIC CONTROL-WAIT AND FOLLOW PILOT CAR" sign with black legend on white background at all intersections, driveways and alleys without a flagger within traffic control area. Signs shall be clean and visible at all times. Where traffic can not be effectively self-regulated, at least one flagger shall be used at each intersection within traffic control area.
- An optional C29(CA) sign may be placed below the C9A(CA) sign.
- Either traffic cones or barricades shall be placed on the taper. Barricades shall be Type I, II, or III.
- The color of the portable transverse rumble strips shall be black or orange. Use 2 arrays, each array shall consist of 3 rumble strips.
- Portable transverse rumble strips shall not be placed on sharp horizontal or vertical curves nor shall they be placed through pedestrian crossings.
- If the portable transverse rumble strips become out of alignment (skewed) by more than 6 inches, measured from one end to the other, they shall be readjusted to bring the placement back to the original location.
- Portable transverse rumble strips are not required if any one of the following conditions is satisfied:
  - Work duration occupies a location for four hours or less
  - Posted speed limit is below 45 MPH
  - Work is of emergency nature
  - Work zone is in snow or icy weather conditions

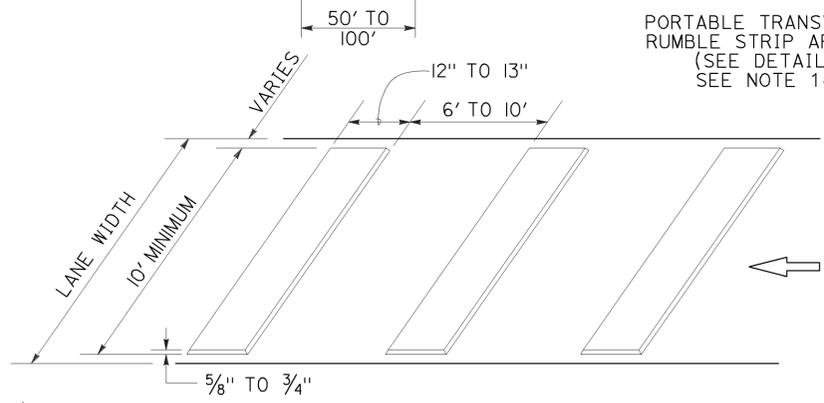

**PORTABLE TRANSVERSE RUMBLE STRIP ARRAY DETAIL**

**SIGN PANEL SIZE (Min)**

- A 48" x 48"
- B 30" x 30"
- C 36" x 18"
- D 36" x 42"
- E 20" x 7"

**LEGEND**

- TRAFFIC CONE
- † TEMPORARY TRAFFIC CONTROL SIGN
- ⊛ PORTABLE FLASHING BEACON
- 🚧 FLAGGER

STATE OF CALIFORNIA  
DEPARTMENT OF TRANSPORTATION

**TRAFFIC CONTROL SYSTEM FOR LANE CLOSURE ON TWO LANE CONVENTIONAL HIGHWAYS**

NO SCALE


RSP T13 DATED OCTOBER 17, 2014 SUPERSEDES RSP T13 DATED JULY 18, 2014 AND RSP T13 DATED APRIL 19, 2013 AND STANDARD PLAN T13 DATED MAY 20, 2011 - PAGE 241 OF THE STANDARD PLANS BOOK DATED 2010.

2010 REVISED STANDARD PLAN RSP T13


DIST	COUNTY	ROUTE	POST MILES TOTAL PROJECT	SHEET No.	TOTAL SHEETS
07	LA	110	11.6/12.3	119	121

REGISTERED CIVIL ENGINEER *YU SONG* 5-1-15 DATE  
 PLANS APPROVAL DATE 5-26-15  
 YU SONG  
 No. C71687  
 Exp. 12/31/15  
 CIVIL  
 STATE OF CALIFORNIA

*The State of California or its officers or agents shall not be responsible for the accuracy or completeness of scanned copies of this plan sheet.*

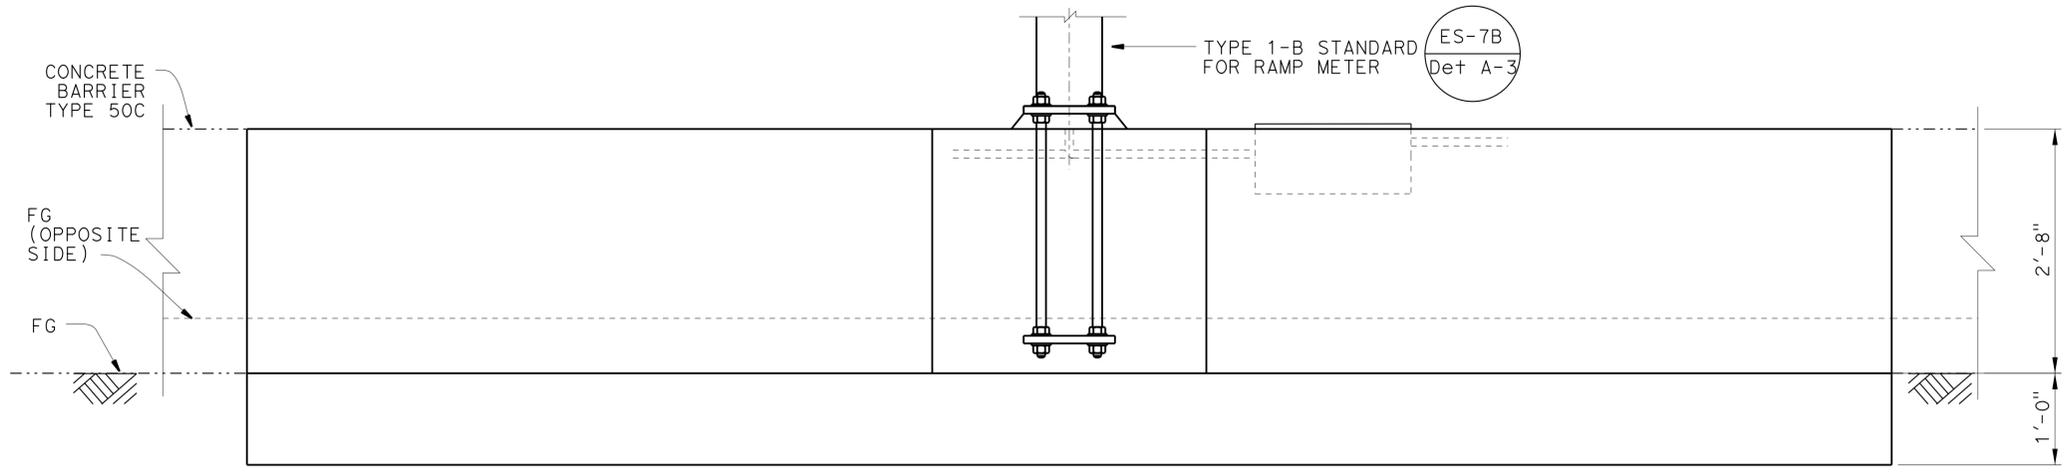


**ELEVATION**  
1" = 1'

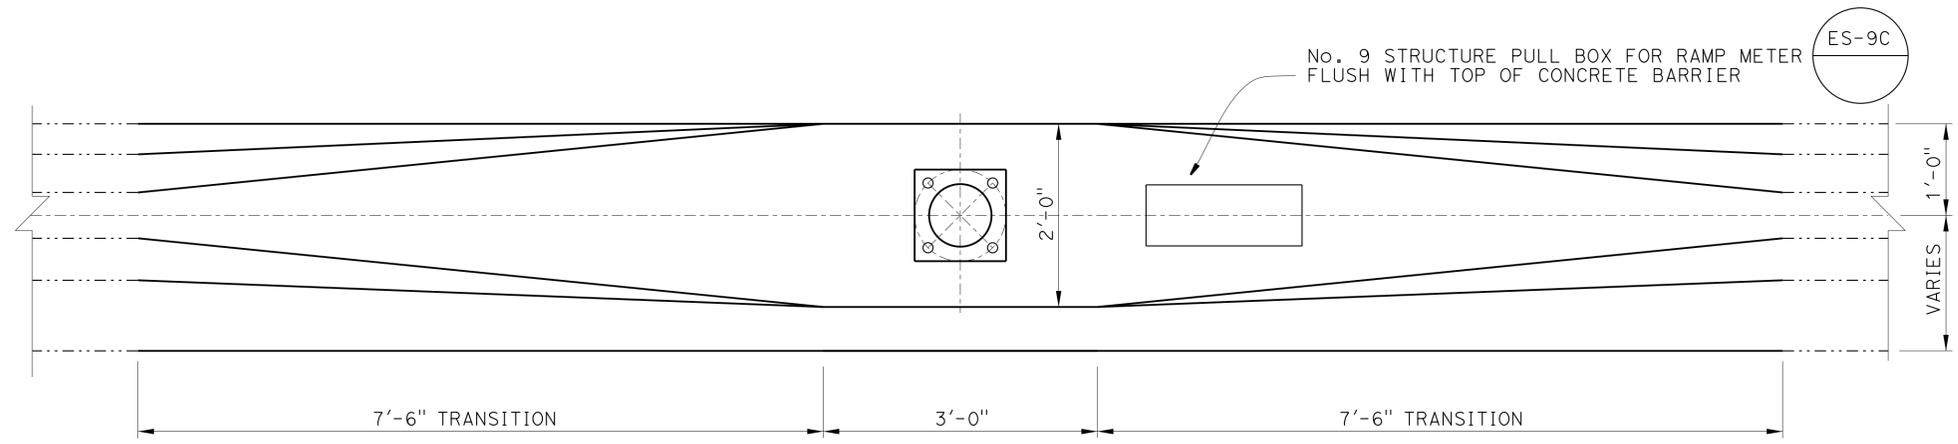


**PLAN**  
1" = 1'


NOTE:  
THE CONTRACTOR MUST VERIFY ALL CONTROLLING FIELD DIMENSIONS BEFORE ORDERING OR FABRICATING ANY MATERIAL.

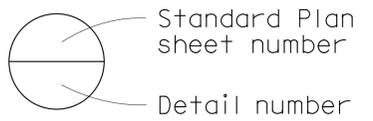


- NOTES:
- For Ramp meter pole location, see "ROADWAY PLANS".
  - Using location of ramp meter pole as center, cut and remove 18' of existing Type 50C barrier with jackhammer, leaving existing rebar undamaged. Sandblast the existing rebar to remove old concrete.
  - Add new rebar for the cut section as shown.
  - Install a No. 9 pull box as shown, it should be flushed with barrier top surface. For No. 9 pull box details, refer to Standard Plan ES-9C. For pull box and conduit installation details, refer to Standard Plan ES-9A and ES-9D.

BRANCH CHIEF <u>DAVID NEUMANN</u>	DESIGN BY YU SONG	CHECKED NIRANJEN KANEPATHIPILLAI	STATE OF CALIFORNIA DEPARTMENT OF TRANSPORTATION	DIVISION OF ENGINEERING SERVICES DESIGN AND TECHNICAL SERVICES SPECIAL DESIGNS BRANCH <b>B</b>	BRIDGE NO. 53-2752S	CONCRETE BARRIER TRANSITION HOV LANE RAMP METER ON TYPE 50C BARRIER (Mod)	SES-1
	DETAILS BY H NGUYEN	CHECKED YU SONG			POST MILE 11.6		
QUANTITIES BY	CHECKED						

 
DIST	COUNTY	ROUTE	POST MILES TOTAL PROJECT	SHEET No.	TOTAL SHEETS
07	LA	110	11.6/12.3	120	121
 REGISTERED CIVIL ENGINEER DATE 5-1-15					
5-26-15 PLANS APPROVAL DATE					
<small>The State of California or its officers or agents shall not be responsible for the accuracy or completeness of scanned copies of this plan sheet.</small>					

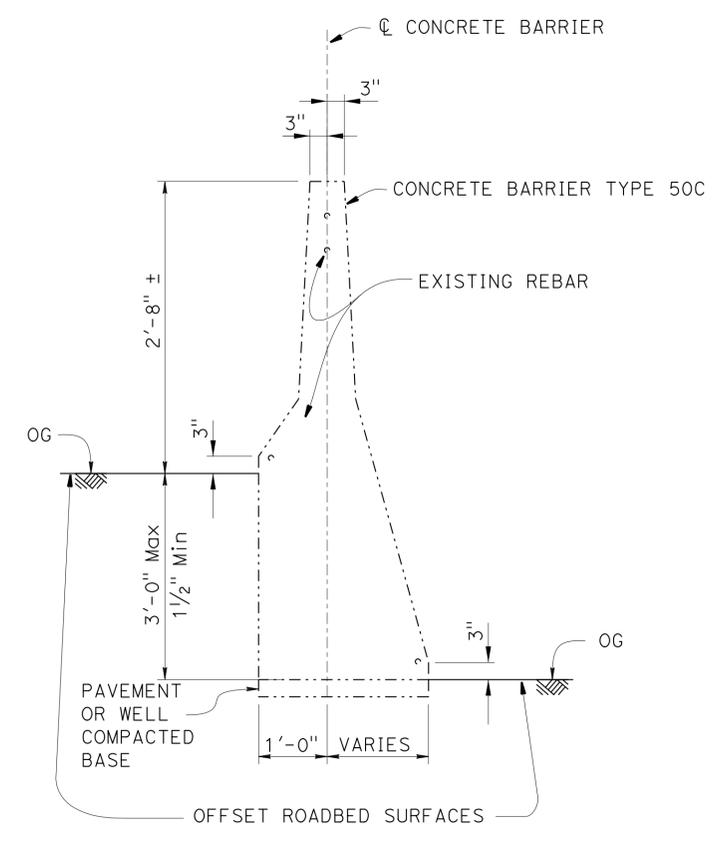


**SECTION A-A**  
3/4" = 1'

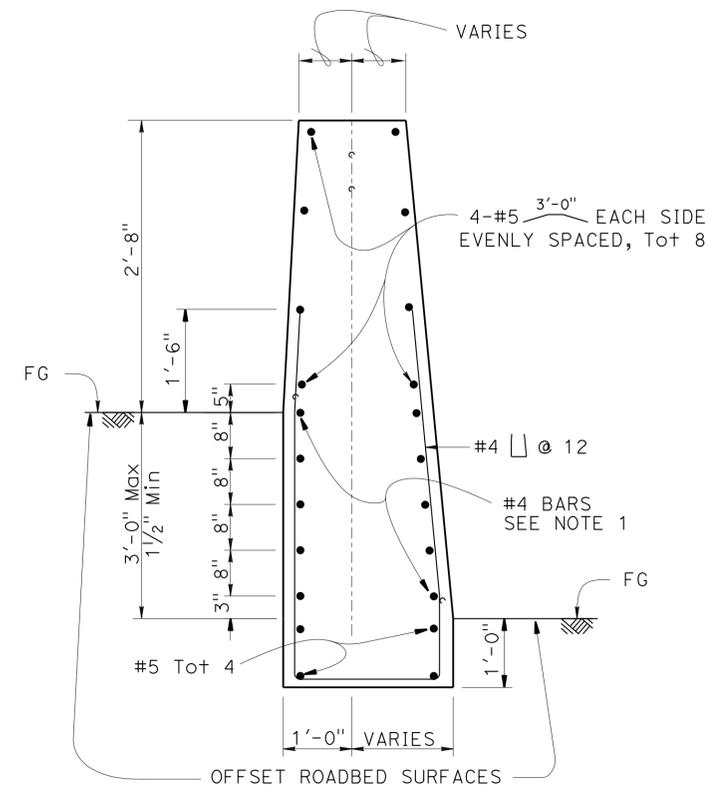

**SECTION B-B**  
3/4" = 1'

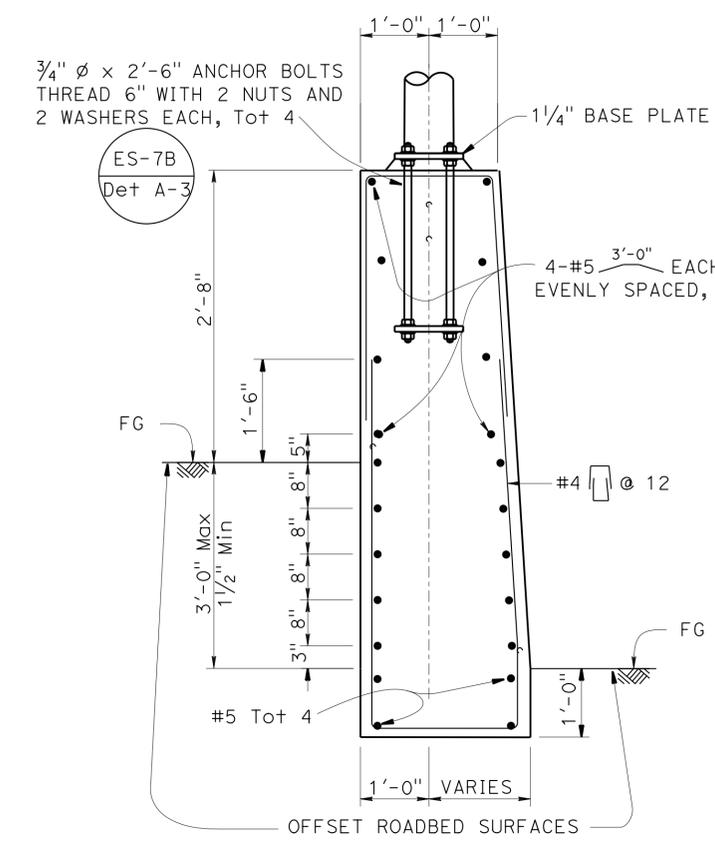

**SECTION C-C**  
3/4" = 1'

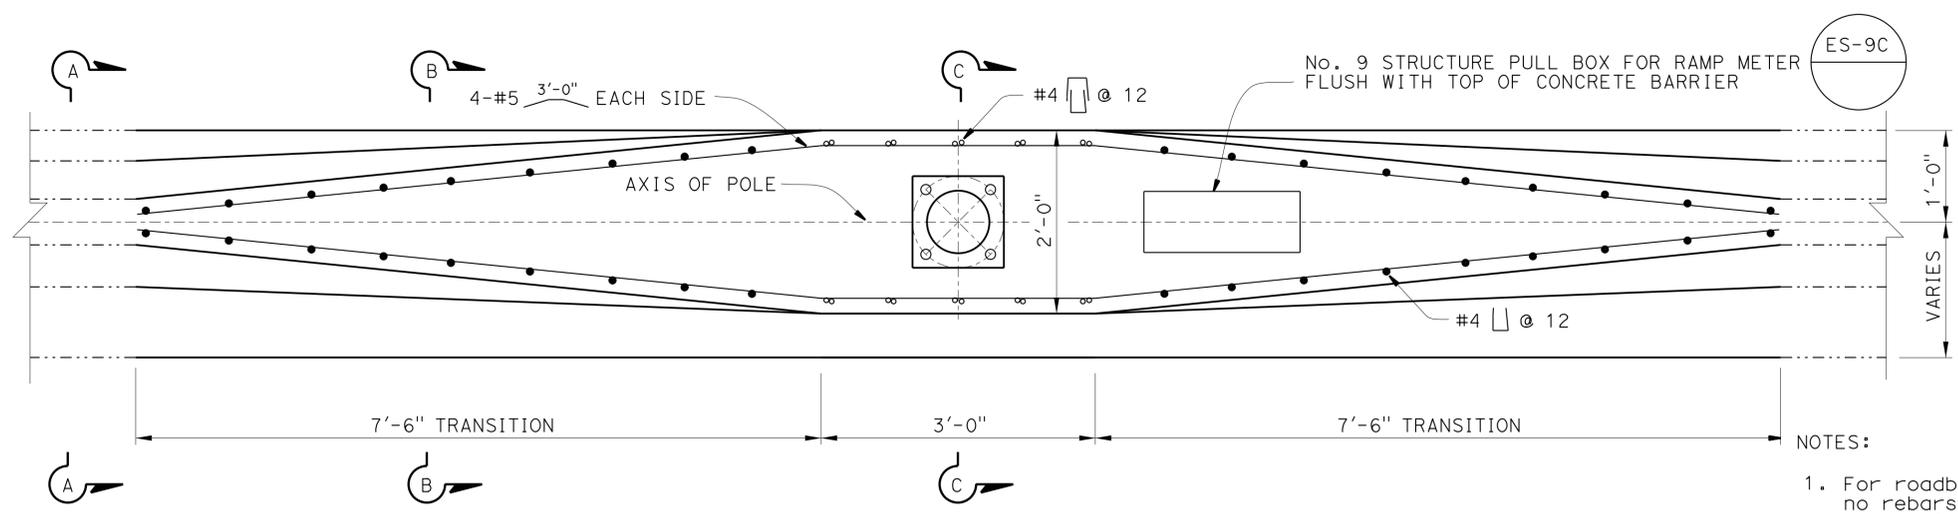

**BARRIER DETAIL AT RAMP METER POLE**  
1" = 1'

NOTES:

- For roadbed surfaces offset greater than 1/2" and less than or equal to 3", no rebars required. For roadbed surfaces offset greater than 3" and less than or equal to 8", use two #4 rebars at 3" above the lower roadbed surface. For roadbed surfaces offset greater than 8" and less than or equal to 12", use two #4 rebars at 3" above the lower roadbed surface and two #4 rebars at 8" above the lower roadbed surface. For roadbed surfaces offset greater than 12" and less than or equal to 36", use two #4 rebars at 3" above the lower roadbed surface and two #4 rebars at every 8" increment vertical spacing above the first two #4 rebars.
- For anchorage of ramp meter pole, refer to Standard Plan ES-7M Detail A.

NOTE:  
THE CONTRACTOR MUST VERIFY ALL CONTROLLING FIELD DIMENSIONS BEFORE ORDERING OR FABRICATING ANY MATERIAL.

BRANCH CHIEF DAVID NEUMANN

DESIGN	BY YU SONG	CHECKED NIRANJEN KANEPATHIPILLAI
DETAILS	BY H NGUYEN	CHECKED YU SONG
QUANTITIES	BY	CHECKED

STATE OF CALIFORNIA  
DEPARTMENT OF TRANSPORTATION

DIVISION OF ENGINEERING SERVICES  
DESIGN AND TECHNICAL SERVICES  
SPECIAL DESIGNS BRANCH **B**

BRIDGE NO.	53-27525
POST MILE	11.6



**CONCRETE BARRIER TRANSITION**  
**HOV LANE RAMP METER ON TYPE 50C BARRIER (Mod)**

**SES-2**


USERNAME => s115484 DATE PLOTTED => 17-JUN-2015 TIME PLOTTED => 15:48

DIST	COUNTY	ROUTE	POST MILES TOTAL PROJECT	SHEET No	TOTAL SHEETS
07	LA	110	11.6/12.3	120	121

Mahfoud A. Licha 5-1-15  
 REGISTERED CIVIL ENGINEER DATE  
 5-26-15  
 PLANS APPROVAL DATE  
 No. C62816  
 Exp. 6/30/16  
 CIVIL  
 STATE OF CALIFORNIA  
 The State of California or its officers or agents shall not be responsible for the accuracy or completeness of electronic copies of this plan sheet.

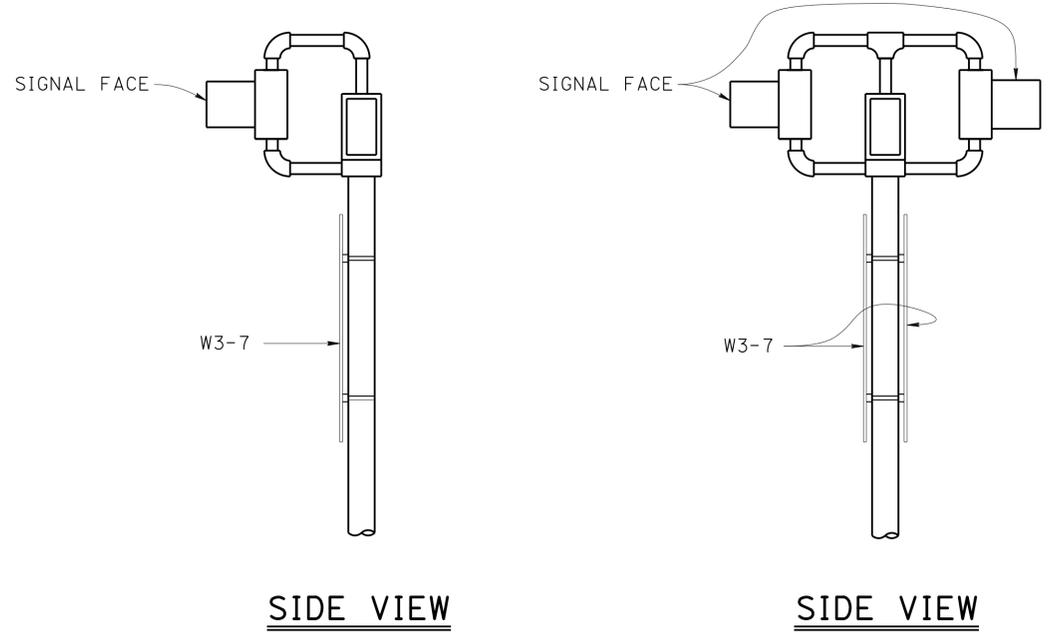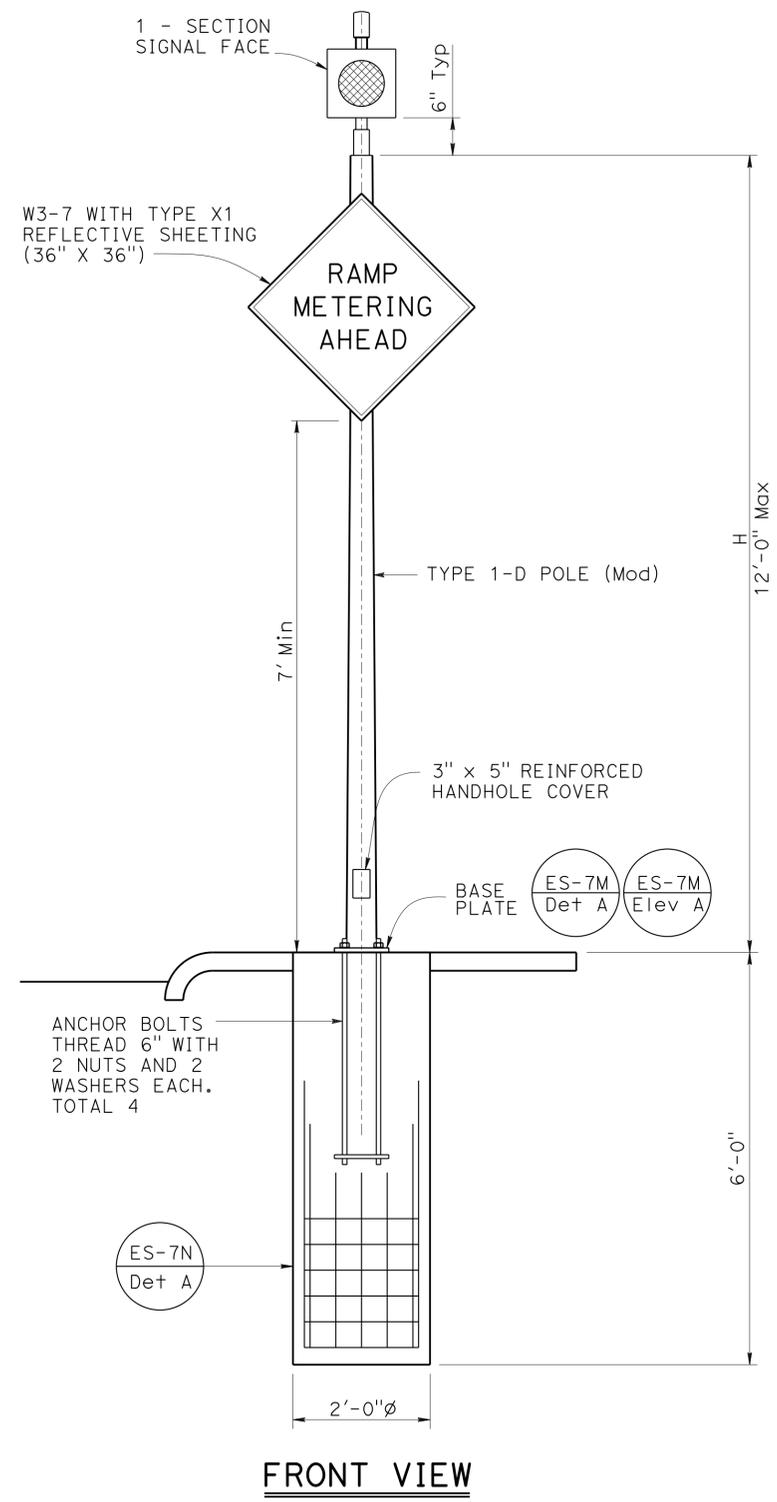

POLE TYPE	POLE DATA			BASE PLATE DATA				
	H HEIGHT	Min OD		THICKNESS	C	BC = BOLT CIRCLE	THICKNESS	ANCHOR BOLTS SIZE
1-D (MODIFIED)	12'-0"	5 1/4"	3 3/8"	0.1196"	9 1/2"	8 1/2"	3/4" Min	1" $\phi$ x 3'-0"

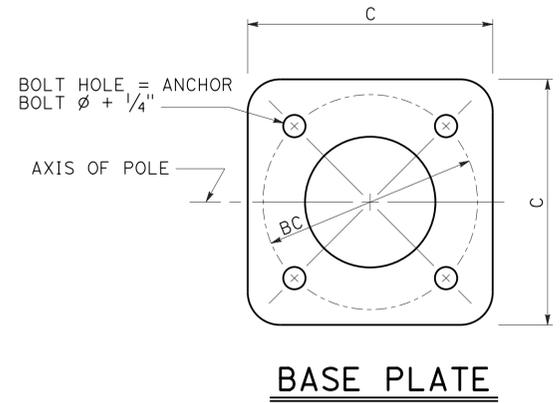

**GENERAL NOTES:**

**SPECIFICATIONS**

Design: AASHTO standard specifications for structural supports for highway signs, luminaires and traffic signals, sixth edition.

**LOADING**

Wind Loading: 100 mph (3-sec gust)

**UNIT STRESSES**

Structural Steel:  $f_y = 55,000$  PSI tapered steel tube  
 $f_y = 50,000$  PSI unless otherwise noted.

 
Anchor Bolts:  $f_y = 55,000$  PSI

Reinforced Concrete:  $f'_c = 3,600$  PSI  
 $f_y = 60,000$  PSI

**NOTES:**

- For pole locations, see "Roadway Plans".
- All steel must be galvanized after fabrication.
- During pole erection the pole must be raked as necessary with the use of leveling nuts to provide a plumb pole axis.
- The foundation must be treated as level ground condition if the slope inclination is flatter than 4H:1V.
- Foundation design is based on AASHTO LTS-6 Article 13.6 Broms' approximate procedure assuming a cohesionless material. The angle of internal friction used is 30 degrees and unit weight of soil is 120 lb/ft<sup>3</sup>.
- W3-7 Sign, unless otherwise noted, must be mounted to pole with stainless steel straps or other method without drilling holes in pole.
- For details not shown, see "2010 STANDARD PLANS" and "2010 REVISED STANDARD PLANS".
- Handhole must be located on down side of traffic.

NOTE:  
 THE CONTRACTOR MUST VERIFY ALL CONTROLLING FIELD DIMENSIONS BEFORE ORDERING OR FABRICATING ANY MATERIAL.



BRANCH CHIEF JEFF WOODY

DESIGN	BY MAHFOUD LICHA	CHECKED ELISEO LOPEZ
DETAILS	BY T. NGUYEN	CHECKED ELISEO LOPEZ
QUANTITIES	BY	CHECKED

STATE OF CALIFORNIA  
 DEPARTMENT OF TRANSPORTATION

DIVISION OF ENGINEERING SERVICES  
 DESIGN AND TECHNICAL SERVICES  
 SPECIAL DESIGNS BRANCH

NO SCALE  
 BRIDGE NO. N/A  
 POST MILE Var

RAMP METER FLASHING BEACON  
 POLE DETAILS

SES-3